

BAWA ASSOCIATES

NOTES

1. The drawing is the copyright of the architect and is not to be reproduced, copied, or handed over to a third party or used for any purpose other than that for which it is issued.
2. Do not scale off this drawing.
3. All dimensions are in feet unless otherwise stated.
4. This drawing is to be read in conjunction with relevant architectural, structural, and services engineers' drawings and specifications, and any other documents, drawings and specifications, at the start of work.
5. All dimensions shall be checked on site prior to the start of work.
6. Written dimensions shall be followed.
7. Any change or discrepancy required shall be confirmed by the architect prior to the start of work.

ONLY FOR DISCUSSION

Project Title
PROPOSED RESIDENCE FOR MR.

BAWA ASSOCIATES
 ER. GOVIND SINGH 836099223
 BAWA 9786817462

20 & 100 Laxmi Nagar / Sector 14 / Gurgaon / Haryana / India

Location - Gurgaon, Haryana

Drawing No. 1/23


Date: 11/11/2023

Scale: 1/4" = 1'-0"

Sheet: 1/23

Client: ER. GOVIND SINGH

Project: PROPOSED RESIDENCE FOR MR.

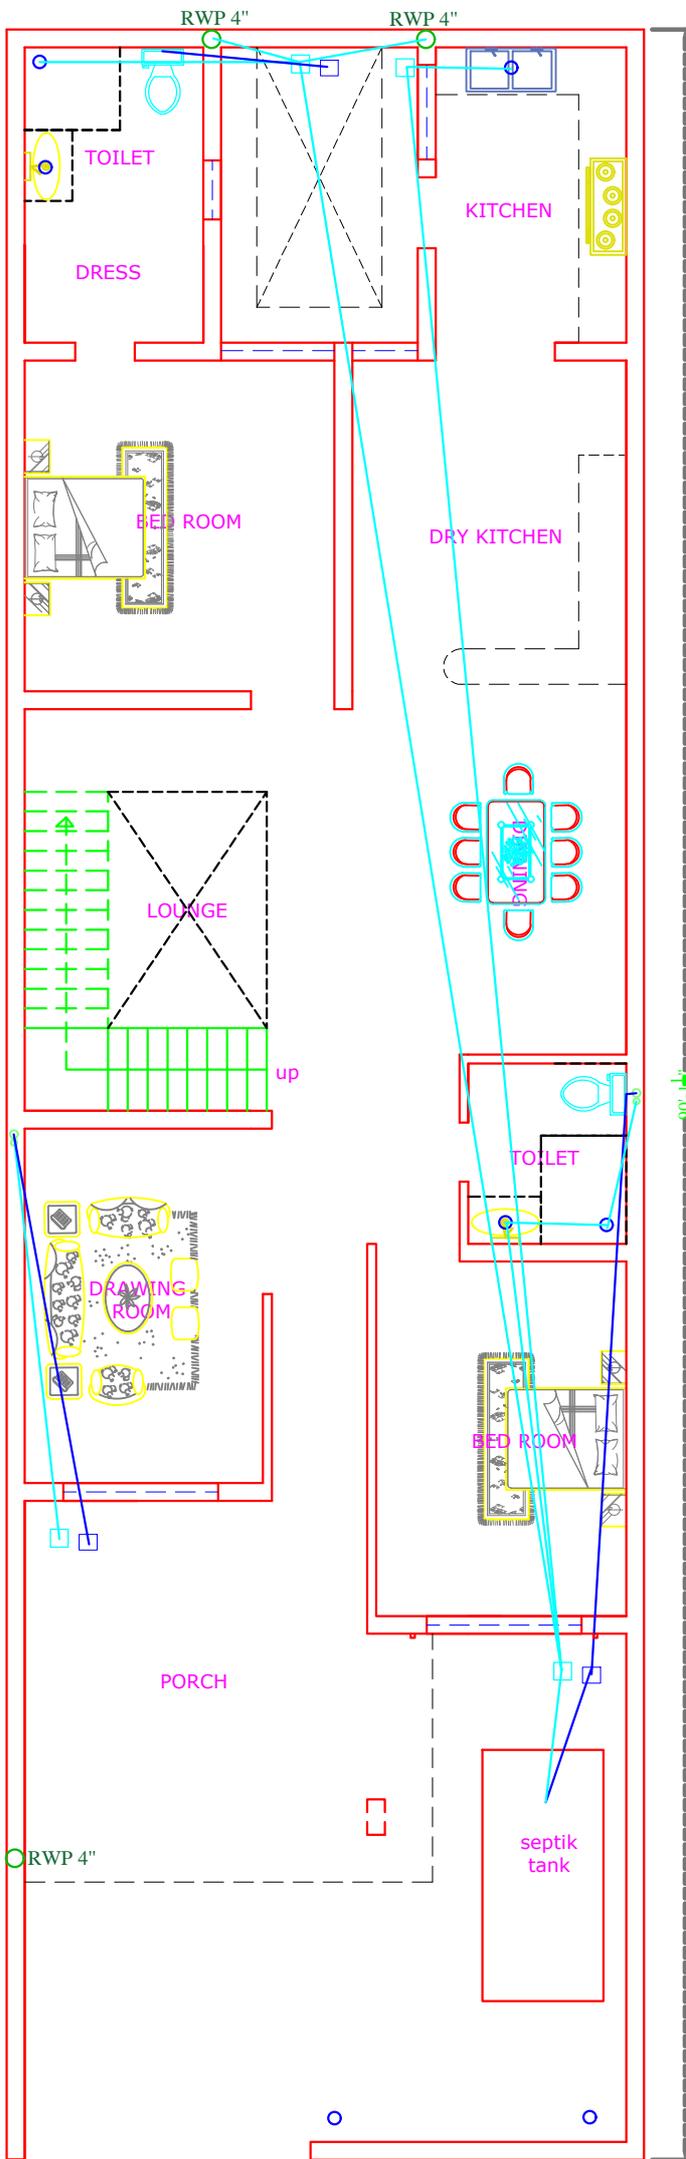

	RWP 4"
	WWP
	SWR
	FTP
	SWR 4"
	WWP
	WWP4"
	SWR4"
	SWR6"
	WWP 6"

BAWA ASSOCIATE
ARCHITECTURAL & INTERIOR DESIGNER

NOTES

1. The drawing is the copyright of the architect and is not to be reproduced, copied, or handed over to a third party or used for any purpose other than that for which it is issued.
2. Do not scale off this drawing.
3. All dimensions are in feet unless otherwise stated.
4. This drawing is to be read in conjunction with relevant architectural, civil/structural, and services engineers' drawings and specifications.
5. All dimensions shall be checked on site prior to the start of work.
6. Written dimensions shall be followed.
7. Any change or discrepancy required shall be confirmed by the architect prior to the start of work.

CAUTION
While every attempt has been made in the preparation of this drawing to avoid mistakes, the maker cannot guarantee against human error. The contractor on the job must check all dimensions and other details and be responsible for the same.

ONLY FOR DISCUSSION

BAWA ASSOCIATES
ER.GOVIND SINGH 8360595223
BAWA 9780817682

2D & 3D Layout Design / Interior Design / Interior Work / Front Elevation / Consultancy Service / Site Visiting / House Renovation Work

Project Title
PROPOSED
RESIDENCE
FOR MR .

Location :-
Sahyadra Patilga

Drawing File
R/Satish Patil - Ground Floor

Scale	Date	Revision
N.T.S	25/11/2022	



BAWA ASSOCIATE

— ARCHITECTURAL & INTERIOR DESIGNER —

CAUTION

While every attempt has been made in the preparation of this drawing to avoid mistakes, the maker cannot guarantee against human error. The contractor on the job must check all dimensions and other details and be responsible for the same.

Stamp & Signature

**ONLY FOR
DISCUSSION**

NOTES

1. The drawing is the copyright of the architect and is not to be reproduced, copied, or handed over to a third party or used for any purpose other than that for which it is issued.
2. Do not scale off this drawing.
3. All dimensions are in feet unless otherwise stated.
4. This drawing is to be read in conjunction with relevant architectural, civil/structural, and services engineers' drawings and specifications.
5. All dimensions shall be checked on site prior to the start of work.
6. Written dimensions shall be followed.
7. Any change or discrepancy required shall be confirmed by the architect prior to the start of work.

BAWA ASSOCIATES

ER.GOVIND SINGH 8360595223
BAWA 9780817682

2D & 3D Layout Designs / Interior Designs / Interior Work /
Front Elevation / Consultancy Service / Site Visiting /
House Renovation Work


Project Title
PROPOSED
RESIDENCE
FOR MR .



Location :-
Sekhpura Patiala

Drawing Title
Front Elevation

Scale	Date	Revision.
N.T.S	25/11/2025

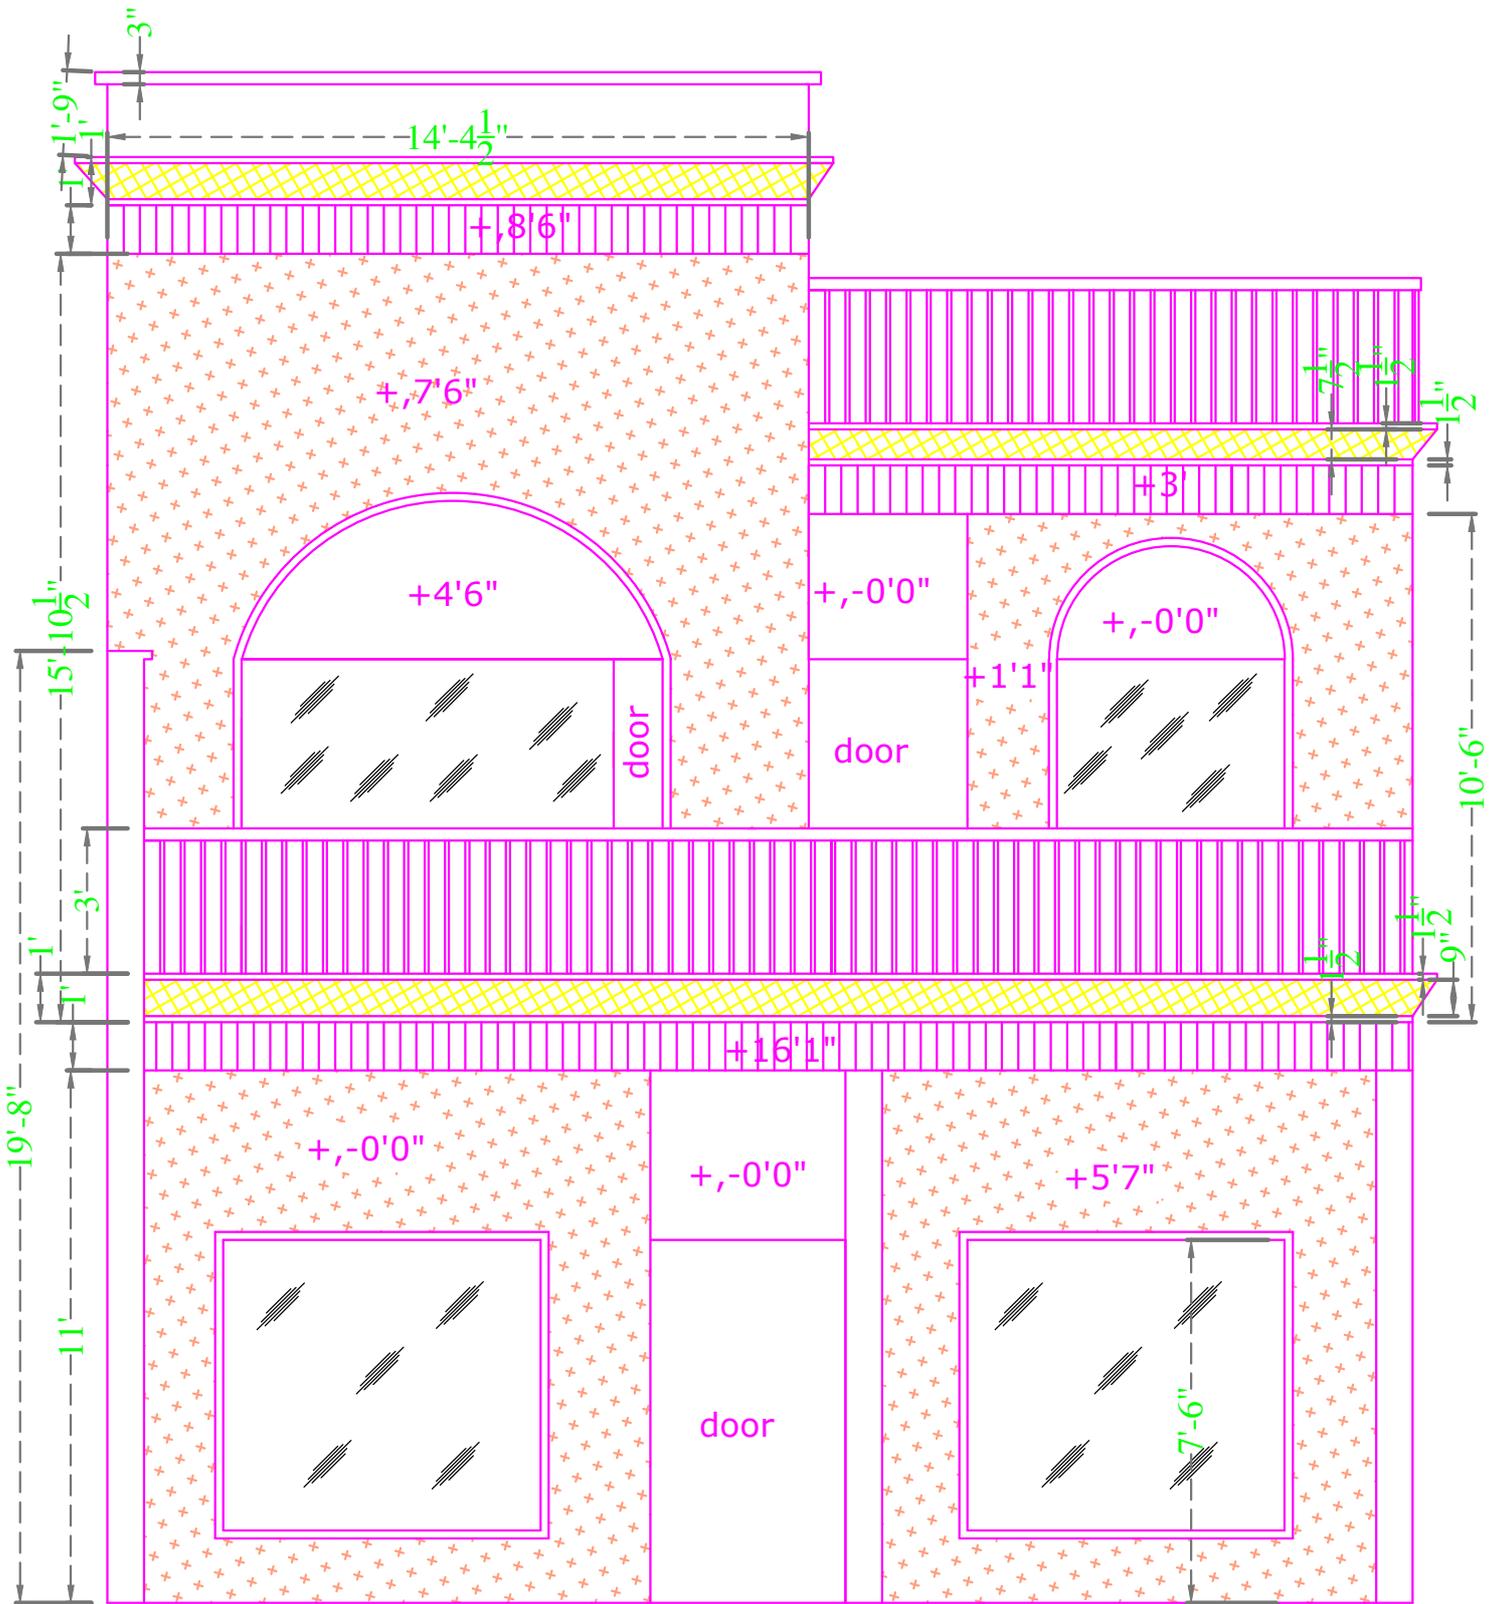

NOTES

1. The drawing is the copyright of the architect and is not to be reproduced, copied, or handed over to a third party or used for any purpose other than that for which it is issued.
2. Do not scale off this drawing.
3. All dimensions are in feet unless otherwise stated.
4. This drawing is to be read in conjunction with relevant architectural, civil/structural, and services engineers' drawings and specifications.
5. All dimensions shall be checked on site prior to the start of work.
6. Written dimensions shall be followed.
7. Any change or discrepancy required shall be confirmed by the architect prior to the start of work.

Stamp & Signature

ONLY FOR DISCUSSION

Project Title
PROPOSED RESIDENCE FOR MR .

BAWA ASSOCIATES
ER.GOVIND SINGH 8360595223
BAWA 9780817682

2D & 3D Layout Designs / Interior Designs / Interior Work / Front Elevation / Consultancy Service / Site Visiting / House Renovation Work




Location :-
Sekhpura Patiala

Drawing Title
Master plan - First Floor

Scale N.T.S	Date 25/11/2025	Revision.
----------------	--------------------	--------------------

CAUTION
While every attempt has been made in the preparation of this drawing to avoid mistakes, the maker cannot guarantee against human error. The contractor on the job must check all dimensions and other details and be responsible for the same.

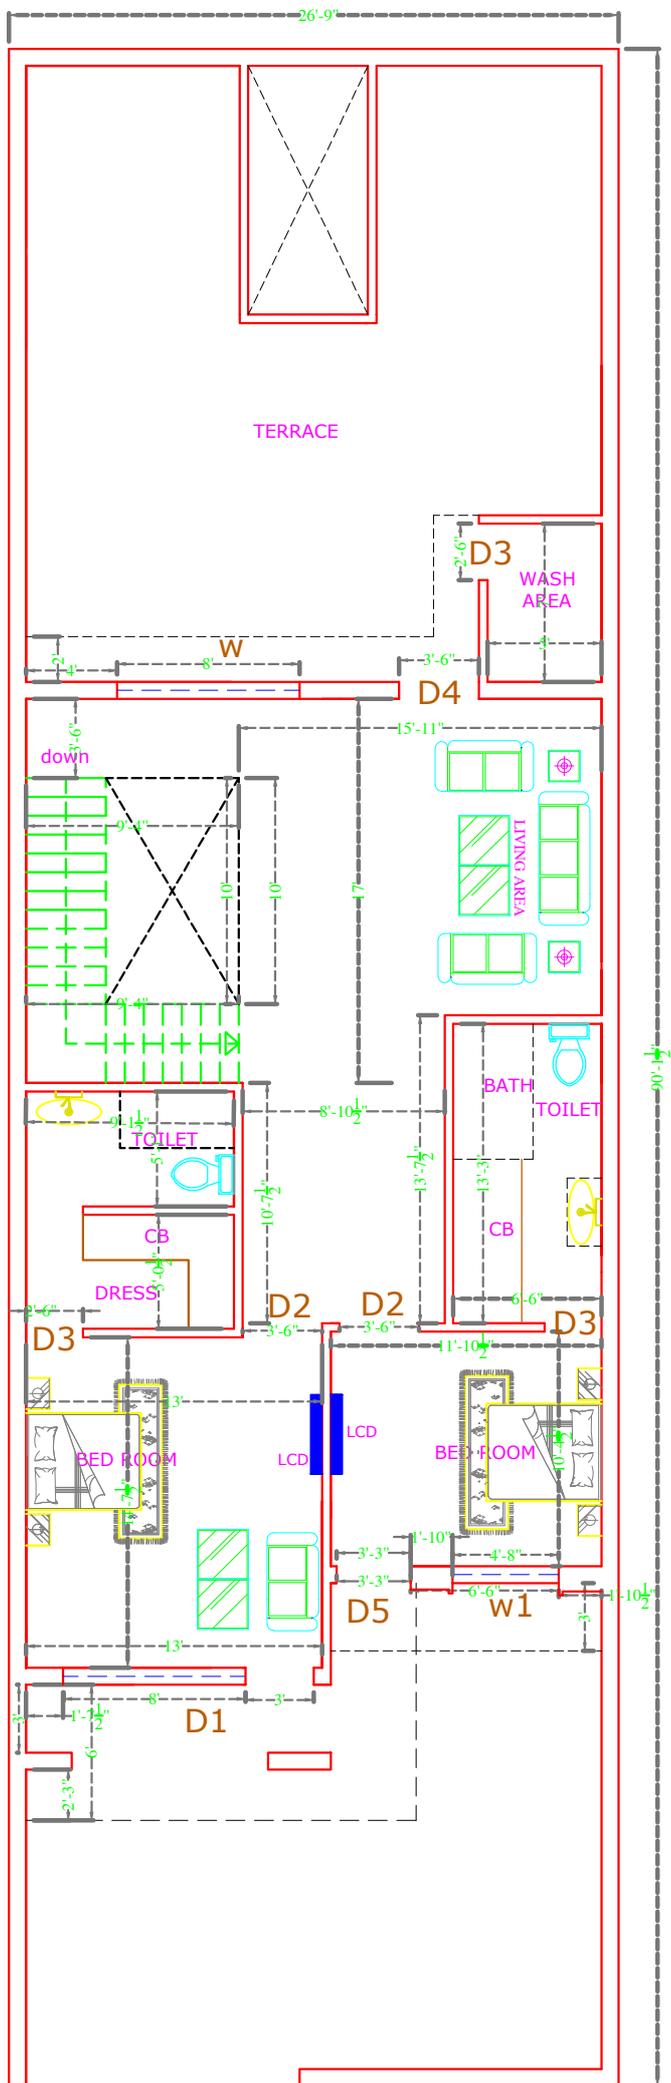

NOTES

1. The drawing is the copyright of the architect and is not to be reproduced, copied, or handed over to a third party or used for any purpose other than that for which it is issued.
2. Do not scale off this drawing.
3. All dimensions are as first unless otherwise stated.
4. This drawing is to be read in conjunction with relevant architectural, structural, and services engineering drawings and specifications, and the list of work.
5. All dimensions shall be in feet and inches.
6. Any change or discrepancy required shall be confirmed by the architect prior to the start of work.

ONLY FOR DISCUSSION


Project Title
PROPOSED RESIDENCE FOR MR.

BAWA ASSOCIATES
 ER. GOVIND SINGH 836099223
 BAWA 9786817462

2D & 3D Layout Design / Interior Design / Exterior Work / Project Management / Construction Services / Vastu Shastra / Space Optimization Work

Location -
 Sakinaka Flat-6

Drawing No. _____
 Scale _____ Date _____
 No. of _____
 No. of _____

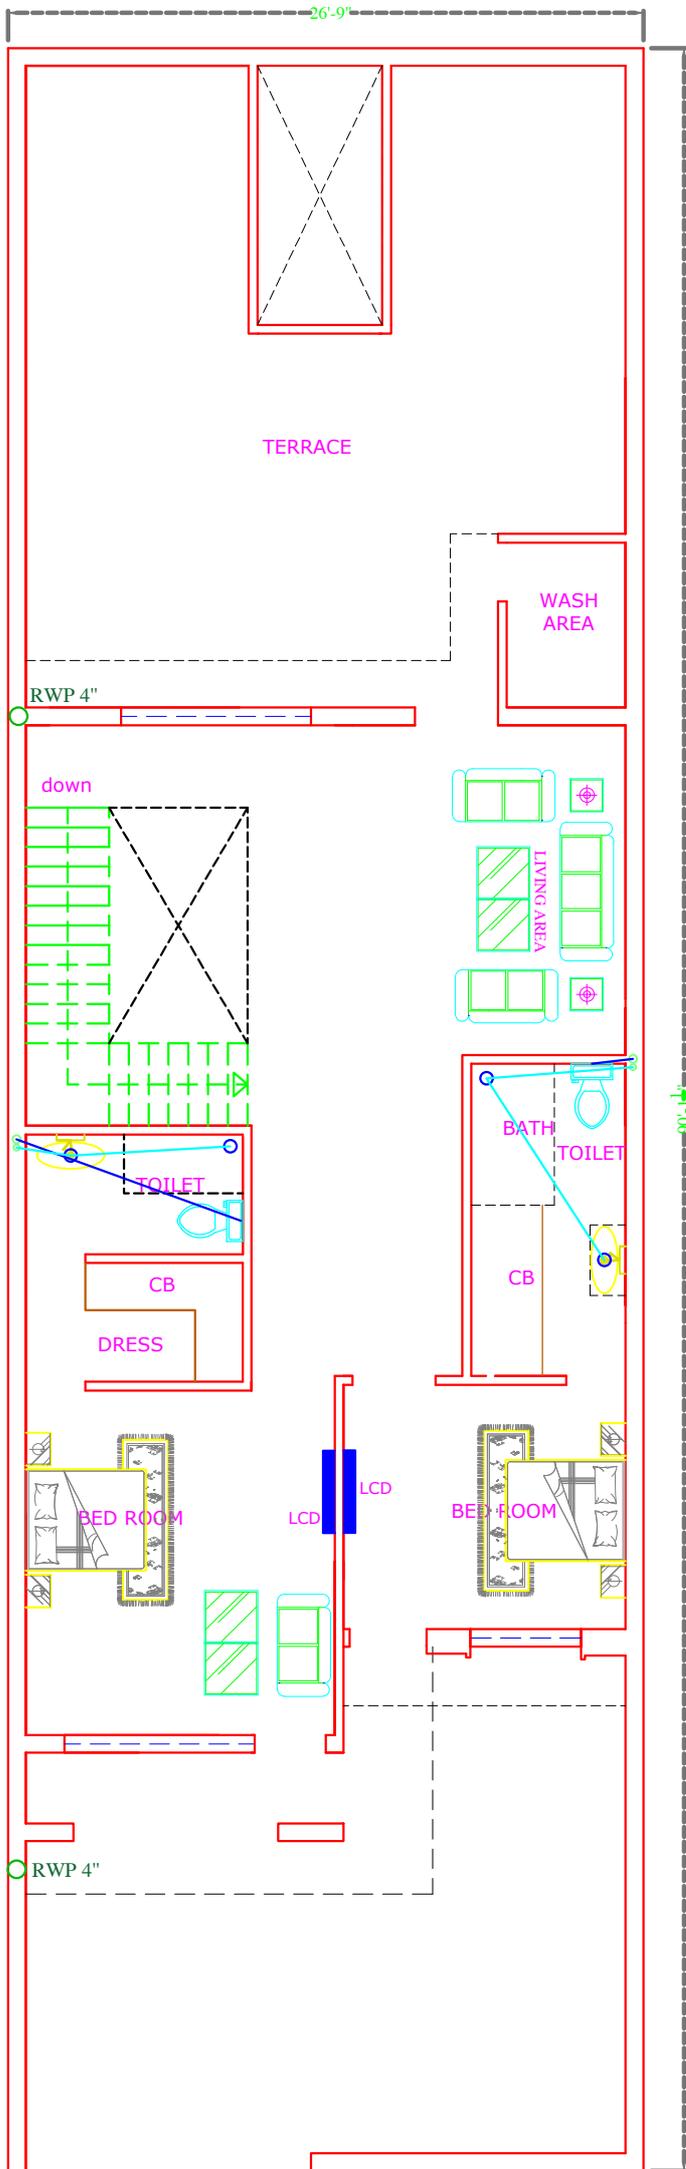

○	RWP 4"
□	WWP
□	SWR
○	FTP
○	SWR 4"
○	WWP
—	WWP 4"
—	SWR 4"
—	SWR 6"
—	WWP 6"



NOTES

1. The drawing is the copyright of the architect and is not to be reproduced, copied, or handed over to a third party or used for any purpose other than that for which it is issued.
2. Do not scale off this drawing.
3. All dimensions are in feet unless otherwise stated.
4. This drawing is to be read in conjunction with relevant architectural, civil, structural, and services engineers' drawings and specifications.
5. All dimensions shall be checked on site prior to the start of work.
6. Written dimensions shall be followed.
7. Any change or discrepancy required shall be confirmed by the architect prior to the start of work.

CAUTION
While every attempt has been made in the preparation of this drawing to avoid mistakes, the maker cannot guarantee against human error. The contractor on the job must check all dimensions and other details and be responsible for the same.

ONLY FOR DISCUSSION

BAWA ASSOCIATES
ER. GOVIND SINGH 8360595223
BAWA 9780817682

2D & 3D Layout Designs / Interior Designs / Interior Work / Front Elevation / Consultancy Services / Site Visiting / House Renovation Work

Project Title
PROPOSED
RESIDENCE
FOR MR .

Location :- Sakinaka Pafala

Drawn By	Checked By	Revised
Scale	Date	
N.T.S.	25/11/2025	



BAWA ASSOCIATE
ARCHITECTURAL & INTERIOR DESIGNER

NOTES

1. The drawing is the copyright of the architect and is not to be reproduced, copied, or handed over to a third party or used for any purpose other than that for which it is issued.
2. Do not scale off this drawing.
3. All dimensions are in feet unless otherwise stated.
4. This drawing is to be read in conjunction with relevant architectural, civil, structural, and services engineers' drawings and specifications.
5. All dimensions shall be checked on site prior to the start of work.
6. Written dimensions shall be followed.
7. Any change or discrepancy required shall be confirmed by the architect prior to the start of work.

CAUTION

While every attempt has been made in the preparation of this drawing to avoid mistakes, the maker cannot guarantee against human error. The contractor on the job must check all dimensions and other details and be responsible for the same.

only for discussion

ONLY FOR DISCUSSION

Project Title

PROPOSED RESIDENCE FOR MR .

BAWA ASSOCIATES

ER.GOVIND SINGH 8360595223
BAWA 9780817682

2D & 3D Layout Designs / Interior Designs / Interior Work /
Front Elevation / Consultancy Service / Site Visiting /
House Renovation Work


Location :-
Sekhpura Patiala


Drawing Title
Joinery Layout - First Floor

Scale
N.T.S

Date
25/11/2025

Revision.
.....

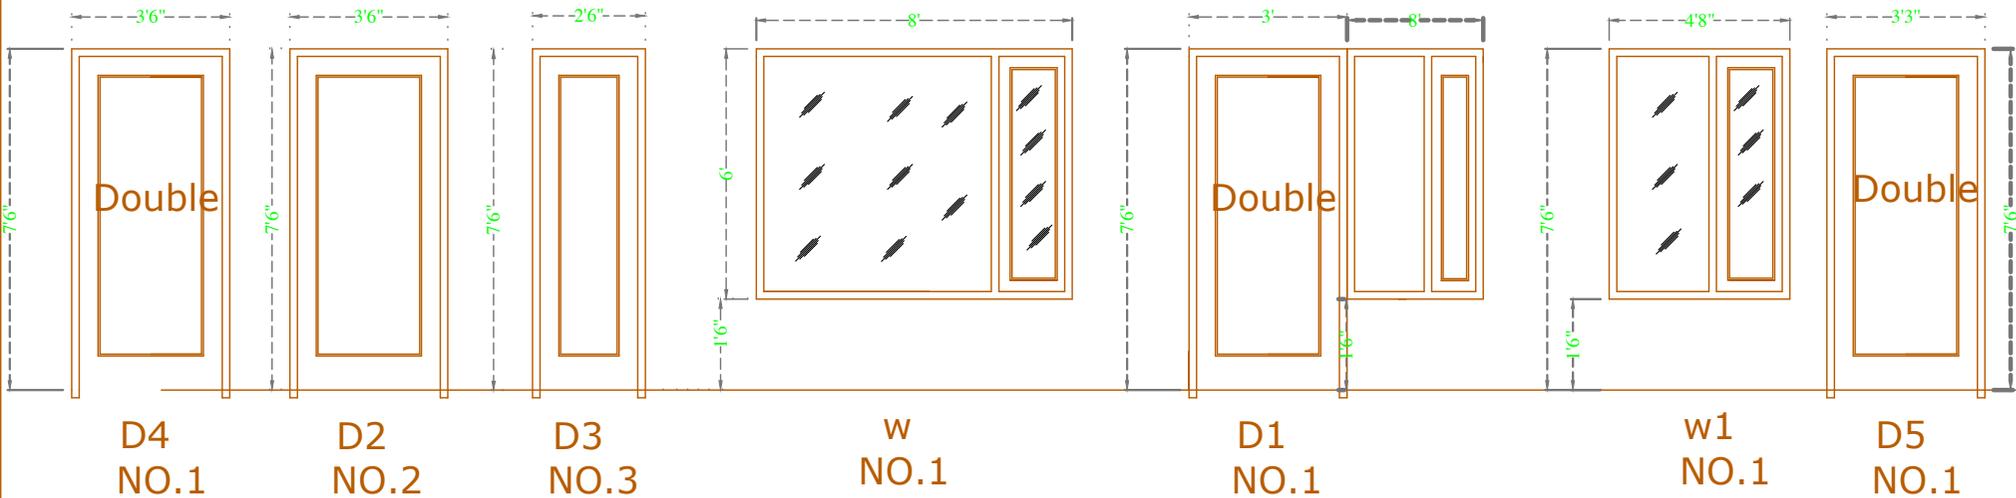

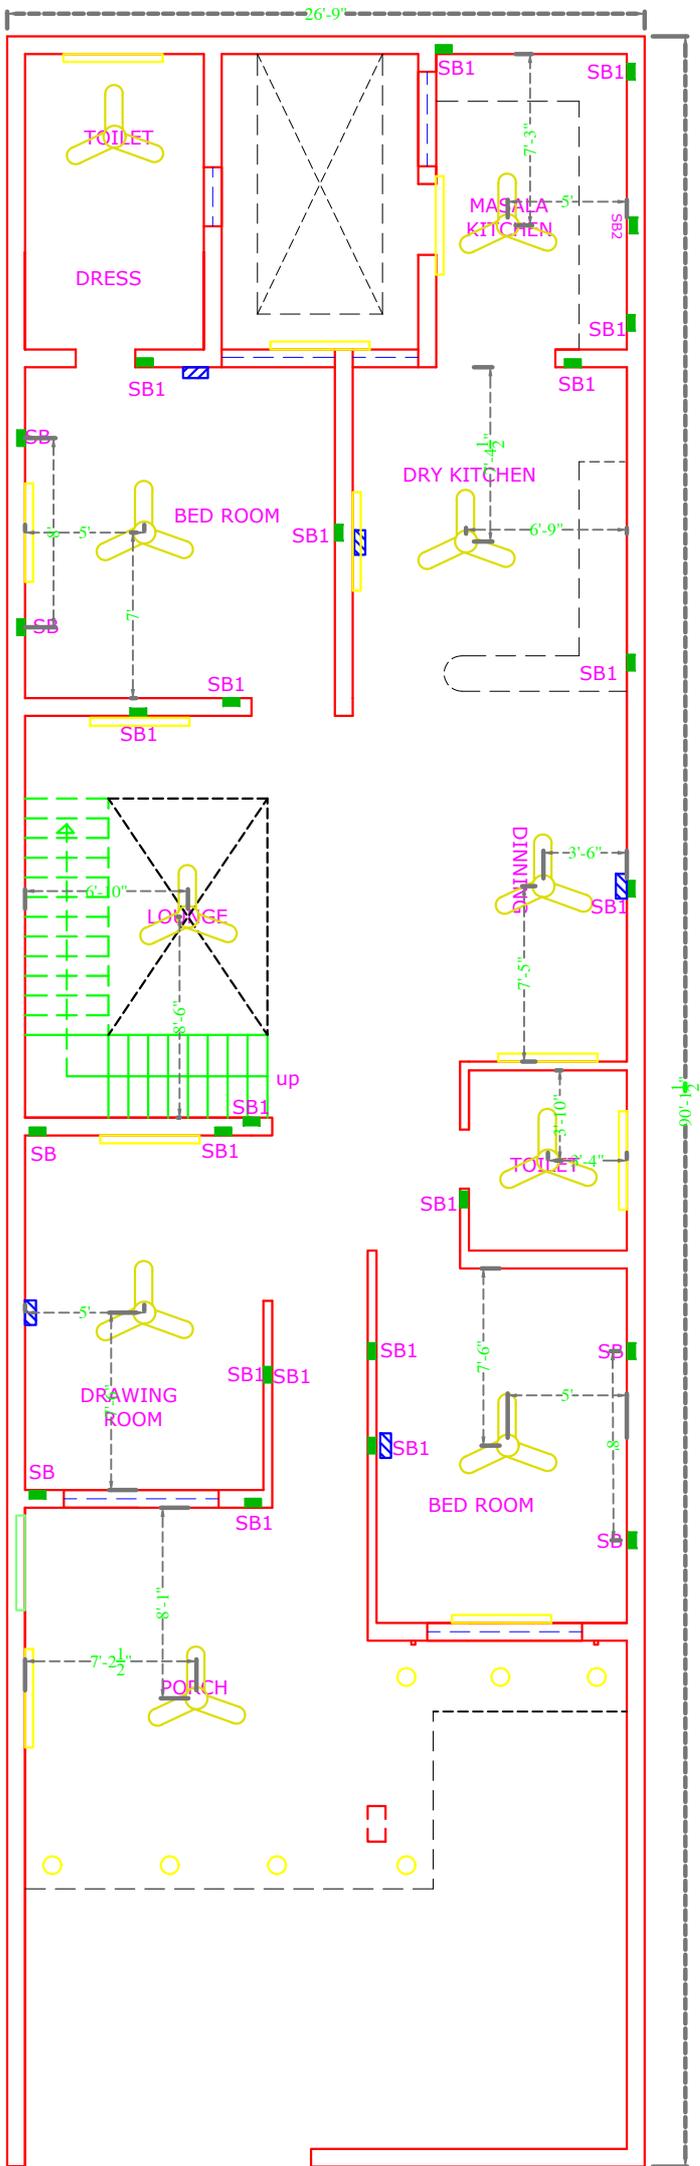

SIGN	NAME	HEIGHT
	SB	2'6"
	SB1	3'6"
	COB	AS
	FAN	AS
	LED TUBE	8'
	MCB	AS
	AC	8'
	SB2	6'



NOTES
 1. The drawing is the copyright of the architect and is not to be reproduced, copied, or handed over to a third party or used for any purpose other than that for which it is issued.
 2. Do not scale off this drawing.
 3. All dimensions are in feet unless otherwise stated.
 4. This drawing is to be read in conjunction with relevant architectural, civil, structural, and services engineers' drawings and specifications.
 5. All dimensions shall be checked on site prior to the start of work.
 6. Written dimensions shall be followed.
 7. Any change or discrepancy required shall be confirmed by the architect prior to the start of work.

CAUTION
 While every attempt has been made in the preparation of this drawing to avoid mistakes, the maker cannot guarantee against human error. The contractor on the job must check all dimensions and other details and be responsible for the same.


ONLY FOR DISCUSSION

BAWA ASSOCIATES
 ER.GOVIND SINGH 8360595223
 BAWA 9780817682
 2D & 3D Layout Design / Interior Design / Interior Work / Front Elevation / Consultancy Services / Site Visiting / House Renovation Work

Project Title
 PROPOSED
 RESIDENCE
 FOR MR .



Location :- Sathya Palanisamy	
Drawing Title Electrical Plan - Ground Floor	Revision
Scale N.T.S	Date 25/11/2022

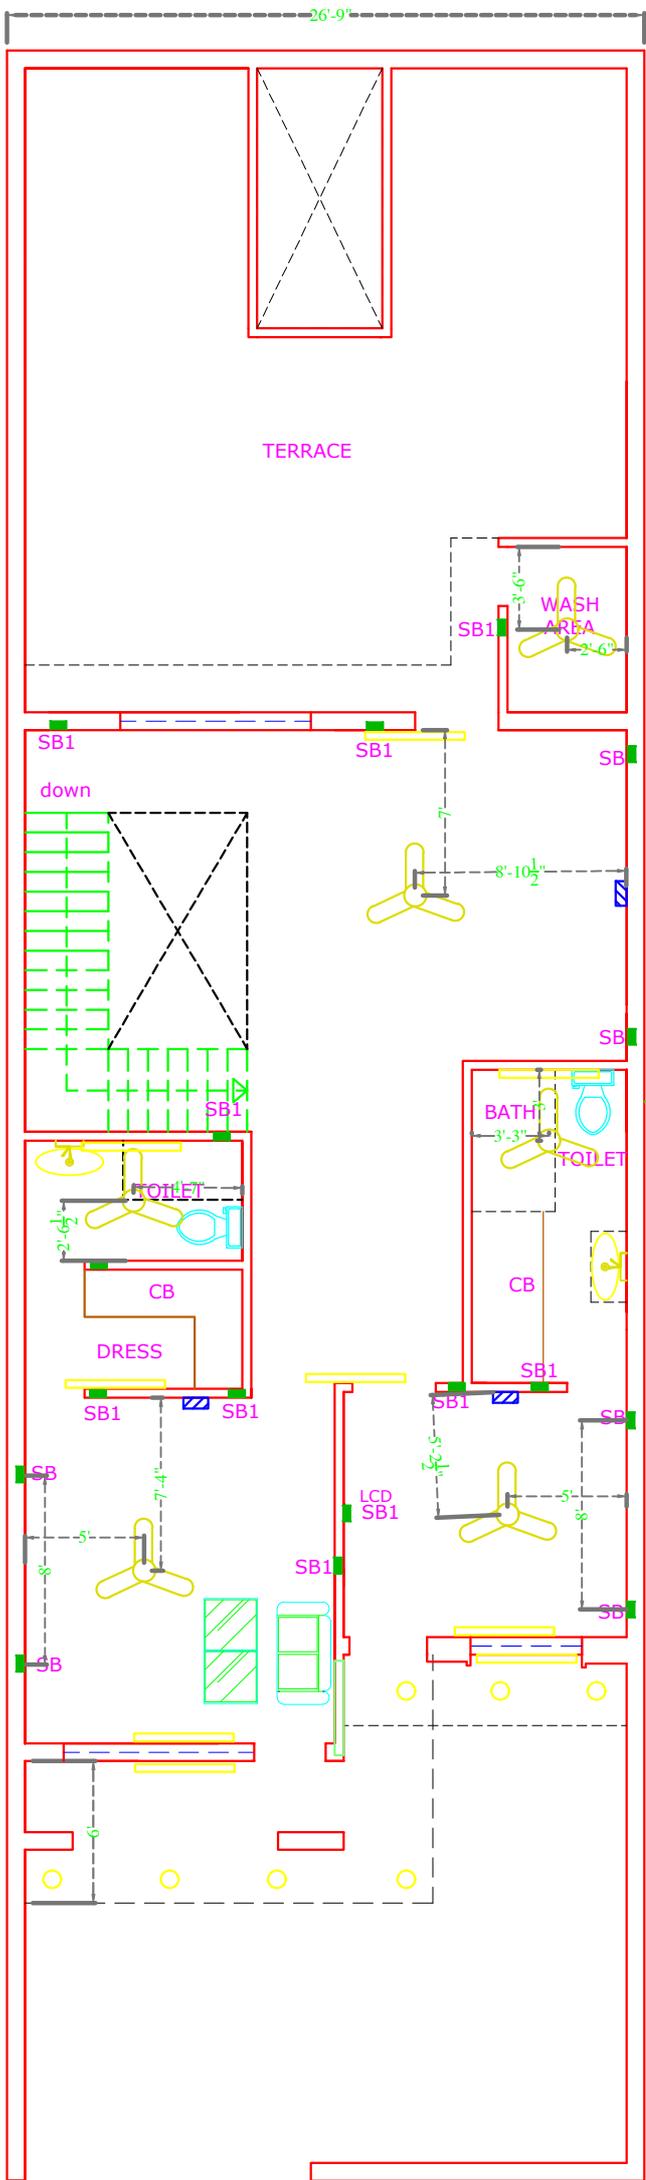

SIGN	NAME	HEIGHT
	SB	2'6"
	SB1	3'6"
	COB	AS
	FAN	AS
	LED TUBE	8'
	MCB	AS
	AC	8'
	SB2	6'



NOTES
 1. The drawing is the copyright of the architect and is not to be reproduced, copied, or handed over to a third party or used for any purpose other than that for which it is issued.
 2. Do not scale off this drawing.
 3. All dimensions are in feet unless otherwise stated.
 4. This drawing is to be read in conjunction with relevant architectural, civil/structural, and services engineers' drawings and specifications.
 5. All dimensions shall be checked on site prior to the start of work.
 6. Written dimensions shall be followed.
 7. Any change or discrepancy required shall be confirmed by the architect prior to the start of work.

CAUTION
 While every attempt has been made in the preparation of this drawing to avoid mistakes, the maker cannot guarantee against human error. The contractor on the job must check all dimensions and other details and be responsible for the same.

ONLY FOR DISCUSSION

BAWA ASSOCIATES
 ER.GOVIND SINGH 8360595223
 BAWA 9780817682
 2D & 3D Layout Design / Interior Design / Interior Work /
 Front Elevation / Consultancy Services / Site Visiting /
 House Renovation Work

Project Title
 PROPOSED
 RESIDENCE
 FOR MR .

Location :-
 Sathya Palata
 Drawing File
 Electrical Plan - First Floor
 Scale
 N.T.S
 Date
 25/11/2025
 Revision

