


**CAUTION**  
While every attempt has been made in the preparation of this drawing to avoid mistakes, the maker cannot guarantee against human error. The contractor on the job must check all dimensions and other details and be responsible for the same.

**NOTES**  
1. The drawing is the copyright of the architect and is not to be reproduced, copied, or handed over to a third party or used for any purpose other than that for which it is issued.  
2. Do not scale off this drawing.  
3. All dimensions are in feet unless otherwise stated.  
4. This drawing is to be read in conjunction with relevant architectural, civil/structural, and services engineers' drawings and specifications.  
5. All dimensions shall be checked on site prior to the start of work.  
6. Written dimensions shall be followed.  
7. Any change or discrepancy required shall be confirmed by the architect prior to the start of work.

*Stamp & Signature*  
**ONLY FOR DISCUSSION**

**Project Title**  
PROPOSED RESIDENCE FOR MR .Aryan

**BAWA ASSOCIATES**  
ER.GOVIND SINGH 8360595223  
BAWA 9780817682  
2D & 3D Layout Designs / Interior Designs / Interior Work / Front Elevation / Consultancy Service / Site Visiting / House Renovation Work

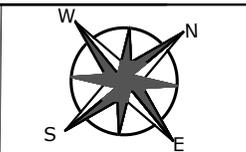

Location :- Punjabi University Patiala		
Drawing Title Master plan Layout plan - First Floor		
Scale N.T.S	Date 09/05/2025	Revision .....



**NOTES**  
 1. The drawing is the copyright of the architect and is not to be reproduced, copied, or handed over to a third party or used for any purpose other than that for which it is issued.  
 2. Do not scale off this drawing.  
 3. All dimensions are in feet unless otherwise stated.  
 4. This drawing is to be read in conjunction with relevant architectural, civil/structural, and services engineers' drawings and specifications.  
 5. All dimensions shall be checked on site prior to the start of work.  
 6. Written dimensions shall be followed.  
 7. Any change or discrepancy required shall be confirmed by the architect prior to the start of work.

**CAUTION**  
 While every attempt has been made in the preparation of this drawing to avoid mistakes, the maker cannot guarantee against human error. The contractor on the job must check all dimensions and other details and be responsible for the same.

**ONLY FOR DISCUSSION**  
**Project Title**  
 PROPOSED RESIDENCE FOR MR .

**BAWA ASSOCIATES**


ER.GOVIND SINGH 8360595223  
 BAWA 9780817682

2D & 3D Layout Designs / Interior Designs / Interior Work / Front Elevation / Consultancy Service / Site Visiting / House Renovation Work

Location :-  
 BAGORA GHANAUR

Drawing Title  
 Joinery Layout - First Floor

Scale N.T.S	Date 22/09/2025	Revision. .....
----------------	--------------------	--------------------

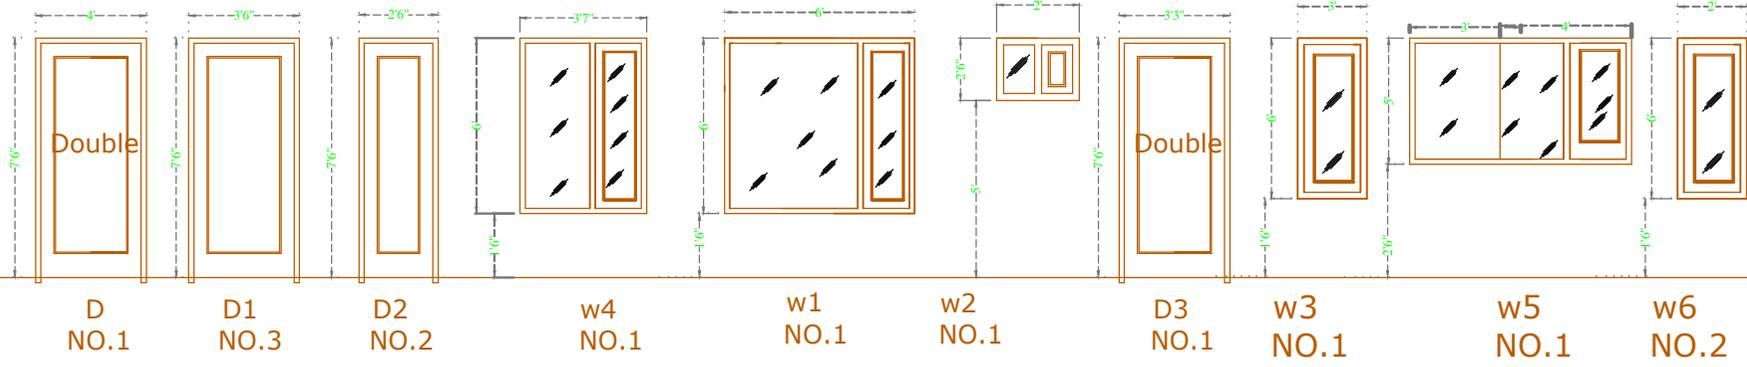



**NOTES**  
 1. The drawing is the copyright of the architect and is not to be reproduced, copied, or handed over to a third party or used for any purpose other than that for which it is issued.  
 2. Do not scale off this drawing.  
 3. All dimensions are in feet unless otherwise stated.  
 4. This drawing is to be read in conjunction with relevant architectural, civil/structural, and services engineers' drawings and specifications.  
 5. All dimensions shall be checked on site prior to the start of work.  
 6. Written dimensions shall be followed.  
 7. Any change or discrepancy required shall be confirmed by the architect prior to the start of work.

**CAUTION**  
 While every attempt has been made in the preparation of this drawing to avoid mistakes, the maker cannot guarantee against human error. The contractor on the job must check all dimensions and other details and be responsible for the same.

**ONLY FOR DISCUSSION**

**Project Title**  
 PROPOSED RESIDENCE FOR MR .

**BAWA ASSOCIATES**


ER.GOVIND SINGH 8360595223  
 BAWA 9780817682


2D & 3D Layout Designs / Interior Designs / Interior Work / Front Elevation / Consultancy Service / Site Visiting / House Renovation Work

Location :-  
 BAGORA GHANAUR

Drawing Title  
 Joinery Layout - First Floor

Scale N.T.S	Date 22/09/2025	Revision. .....
----------------	--------------------	--------------------

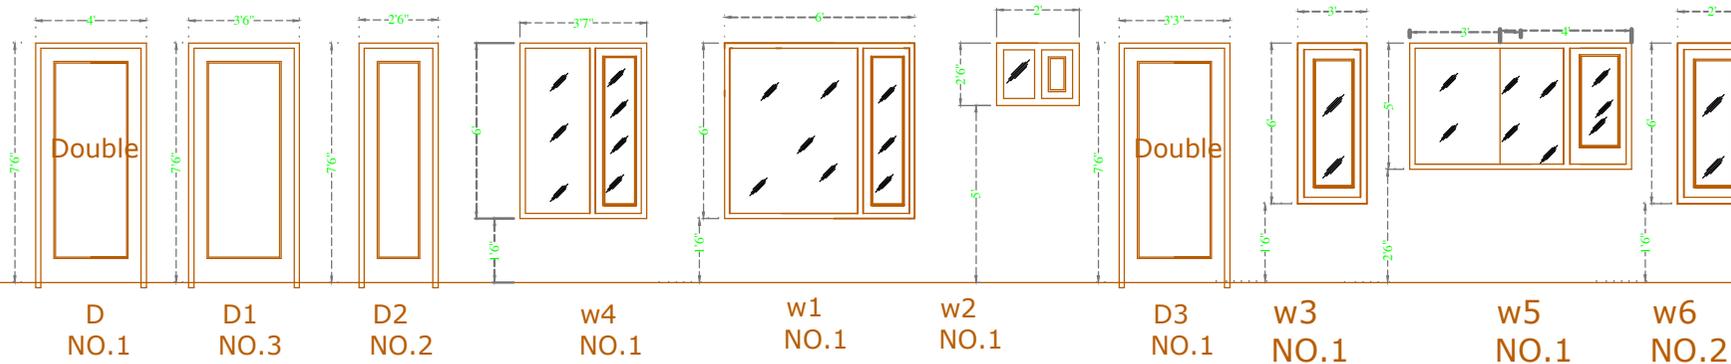

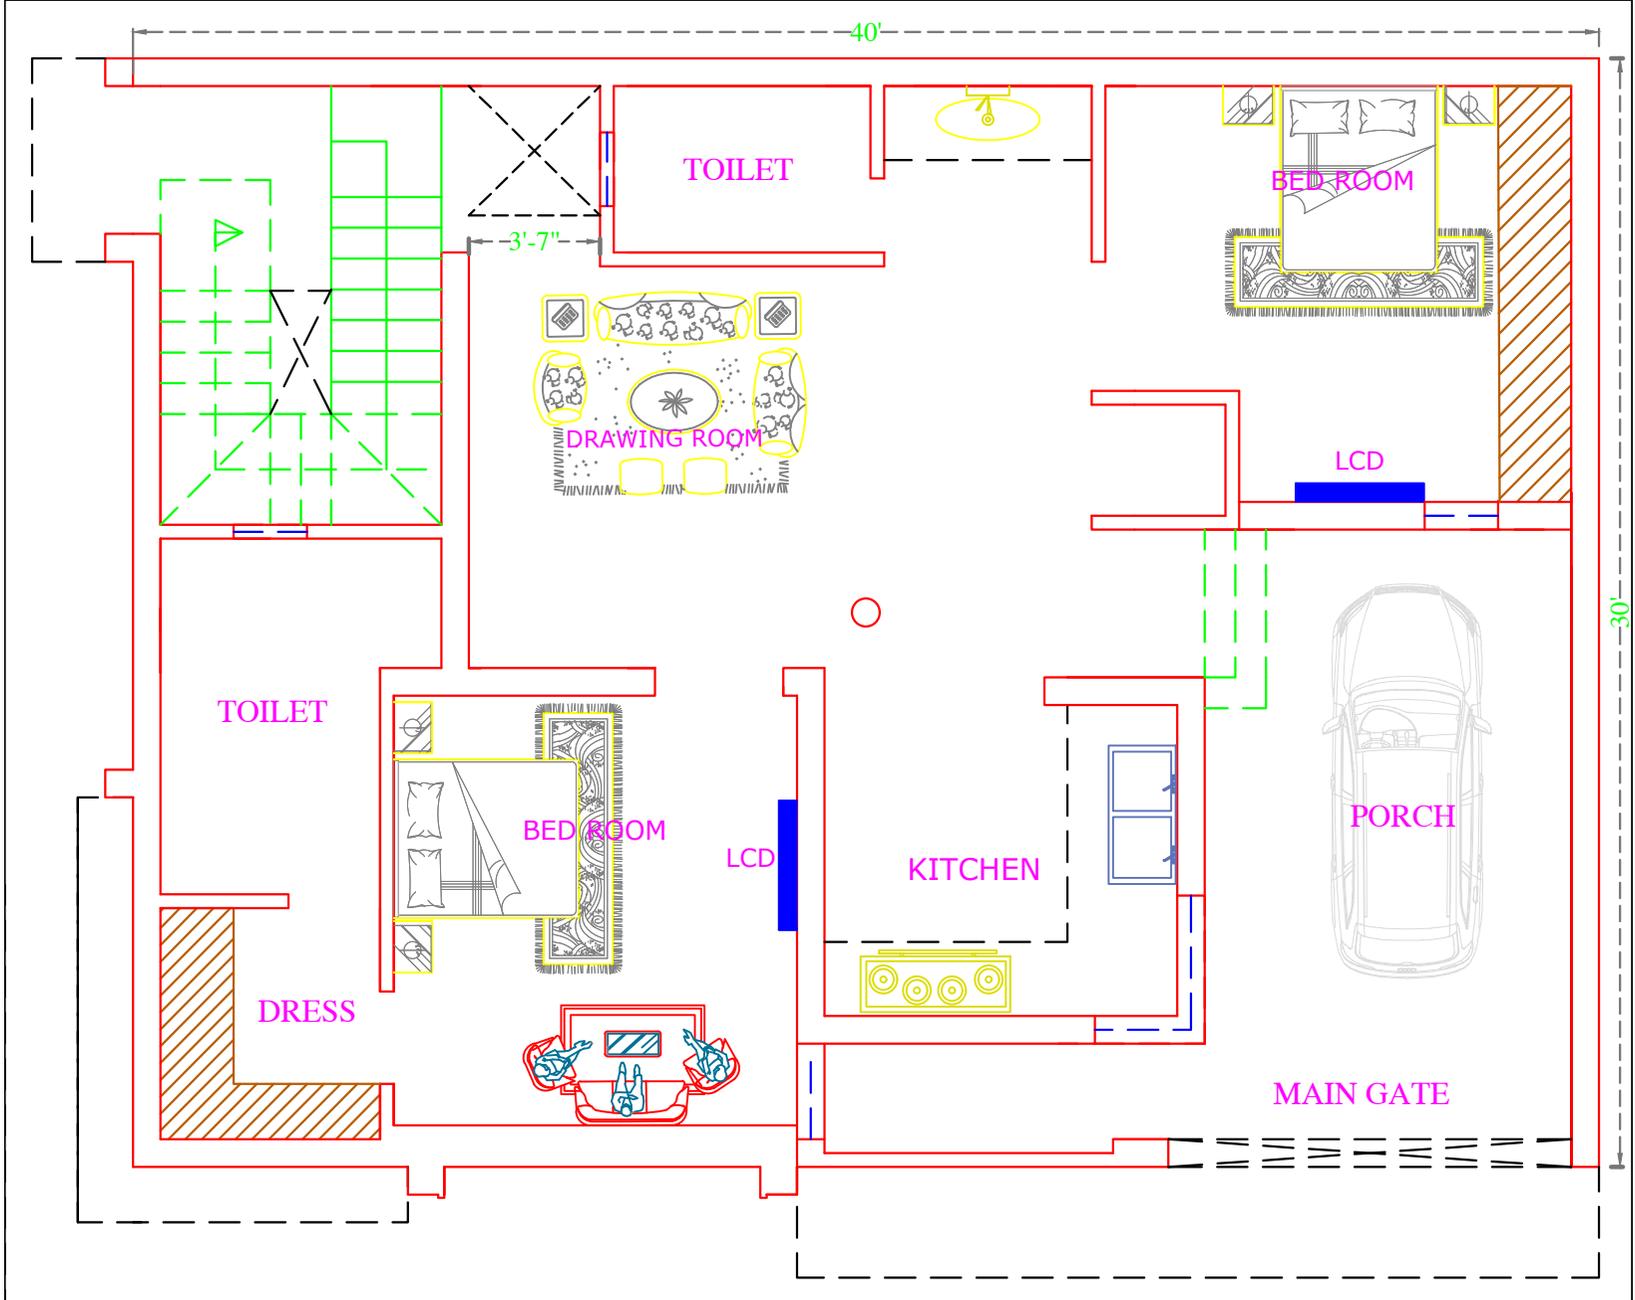

**CAUTION**  
While every attempt has been made in the preparation of this drawing to avoid mistakes, the maker cannot guarantee against human error. The contractor on the job must check all dimensions and other details and be responsible for the same.


**NOTES**

1. The drawing is the copyright of the architect and is not to be reproduced, copied, or handed over to a third party or used for any purpose other than that for which it is issued.
2. Do not scale off this drawing.
3. All dimensions are in feet unless otherwise stated.
4. This drawing is to be read in conjunction with relevant architectural, civil/structural, and services engineers' drawings and specifications.
5. All dimensions shall be checked on site prior to the start of work.
6. Written dimensions shall be followed.
7. Any change or discrepancy required shall be confirmed by the architect prior to the start of work.

Sharp Designs  
**ONLY FOR DISCUSSION**

**Project Title**  
PROPOSED RESIDENCE FOR MR .Aryan

**BAWA ASSOCIATES**  
ER.GOVIND SINGH 8360595223  
BAWA 9780817682  
2D & 3D Layout Designs / Interior Designs / Interior Work / Front Elevation / Consultancy Service / Site Visiting / House Renovation Work

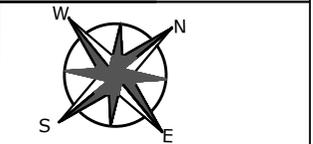

Location :-  
Punjabi University Patiala

Drawing Title  
Master plan Layout plan - Ground Floor

Scale	Date	Revision.
N.T.S	09/05/2025	.....



**NOTES**  
 1. The drawing is the copyright of the architect and is not to be reproduced, copied, or handed over to a third party or used for any purpose other than that for which it is issued.  
 2. Do not scale off this drawing.  
 3. All dimensions are in feet unless otherwise stated.  
 4. This drawing is to be read in conjunction with relevant architectural, civil/structural, and services engineers' drawings and specifications.  
 5. All dimensions shall be checked on site prior to the start of work.  
 6. Written dimensions shall be followed.  
 7. Any change or discrepancy required shall be confirmed by the architect prior to the start of work.

**CAUTION**  
 While every attempt has been made in the preparation of this drawing to avoid mistakes, the maker cannot guarantee against human error. The contractor on the job must check all dimensions and other details and be responsible for the same.



**ONLY FOR DISCUSSION**  
**Project Title**  
 PROPOSED RESIDENCE FOR MR .


**BAWA ASSOCIATES**  
 ER.GOVIND SINGH 8360595223  
 BAWA 9780817682  
**2D & 3D Layout Designs / Interior Designs / Interior Work / Front Elevation / Consultancy Service / Site Visiting / House Renovation Work**

Location :-  
 BAGORA GHANAUR

Drawing Title  
 Joinery Layout - Ground Floor

Scale N.T.S	Date 22/09/2025	Revision. .....
----------------	--------------------	--------------------

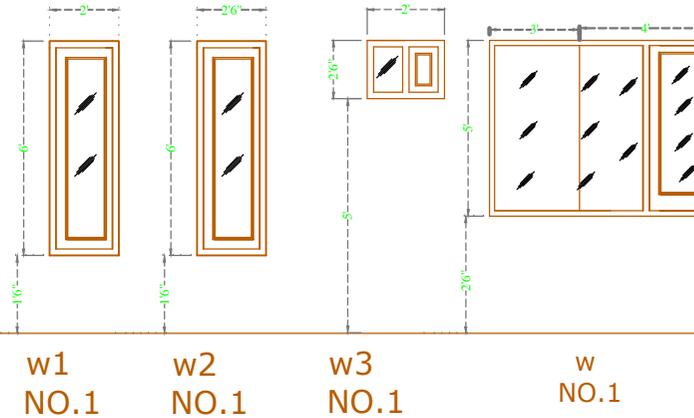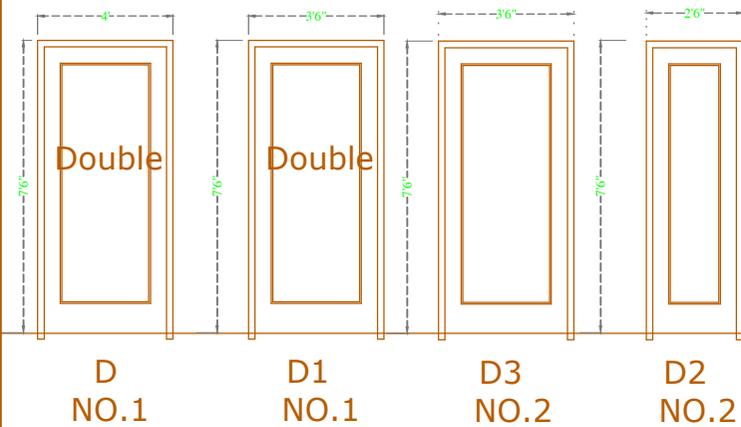

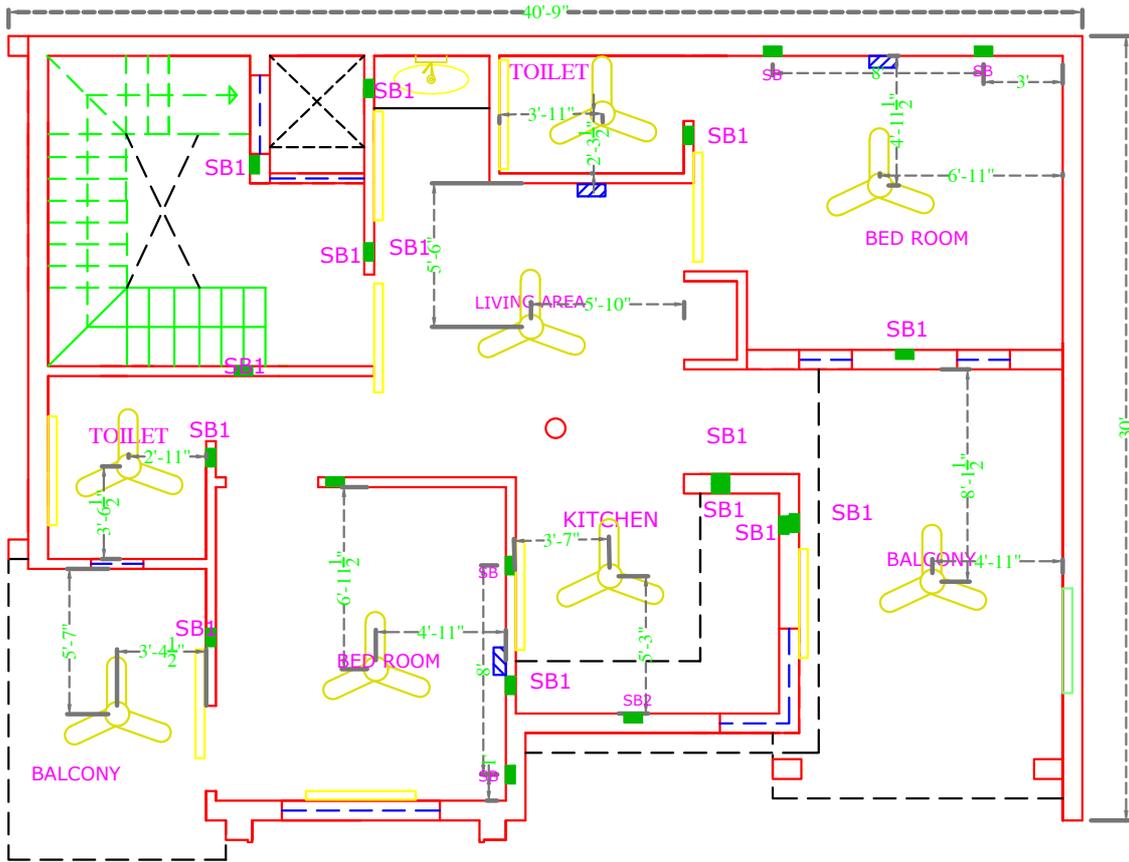

SIGN	NAME	HEIGHT
	SB	2'6"
	SB1	3'6"
	COB	AS
	FAN	AS
	LED TUBE	8'
	MCB	AS
	AC	8'
	SB2	6'



**NOTES**  
 1. The drawing is the copyright of the architect and is not to be reproduced, copied, or handed over to a third party or used for any purpose other than that for which it is issued.  
 2. Do not scale off this drawing.  
 3. All dimensions are in feet unless otherwise stated.  
 4. This drawing is to be read in conjunction with relevant architectural, civil/structural, and services engineers' drawings and specifications.  
 5. All dimensions shall be checked on site prior to the start of work.  
 6. Written dimensions shall be followed.  
 7. Any change or discrepancy required shall be confirmed by the architect prior to the start of work.

**ONLY FOR DISCUSSION**

**Project Title**  
 PROPOSED RESIDENCE FOR MR. Aryan


**BAWA ASSOCIATES**  
 ER.GOVIND SINGH 8360595223  
 BAWA 9780817682

2D & 3D Layout Designs / Interior Designs / Interior Work / Front Elevation / Consultancy Service / Site Visiting / Home Renovation Work




Location :-  
 Punjab University Patiala

Drawing Title	Electrical Layout plan - First Floor
Scale	N.T.S
Date	09/05/2025
Revision	

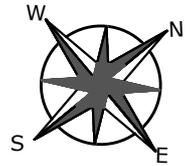

**CUTION**  
 While every attempt has been made in the preparation of this drawing to avoid mistakes, the architect cannot guarantee against human error. The contractor on the job must check all dimensions and other details and be responsible for the same.

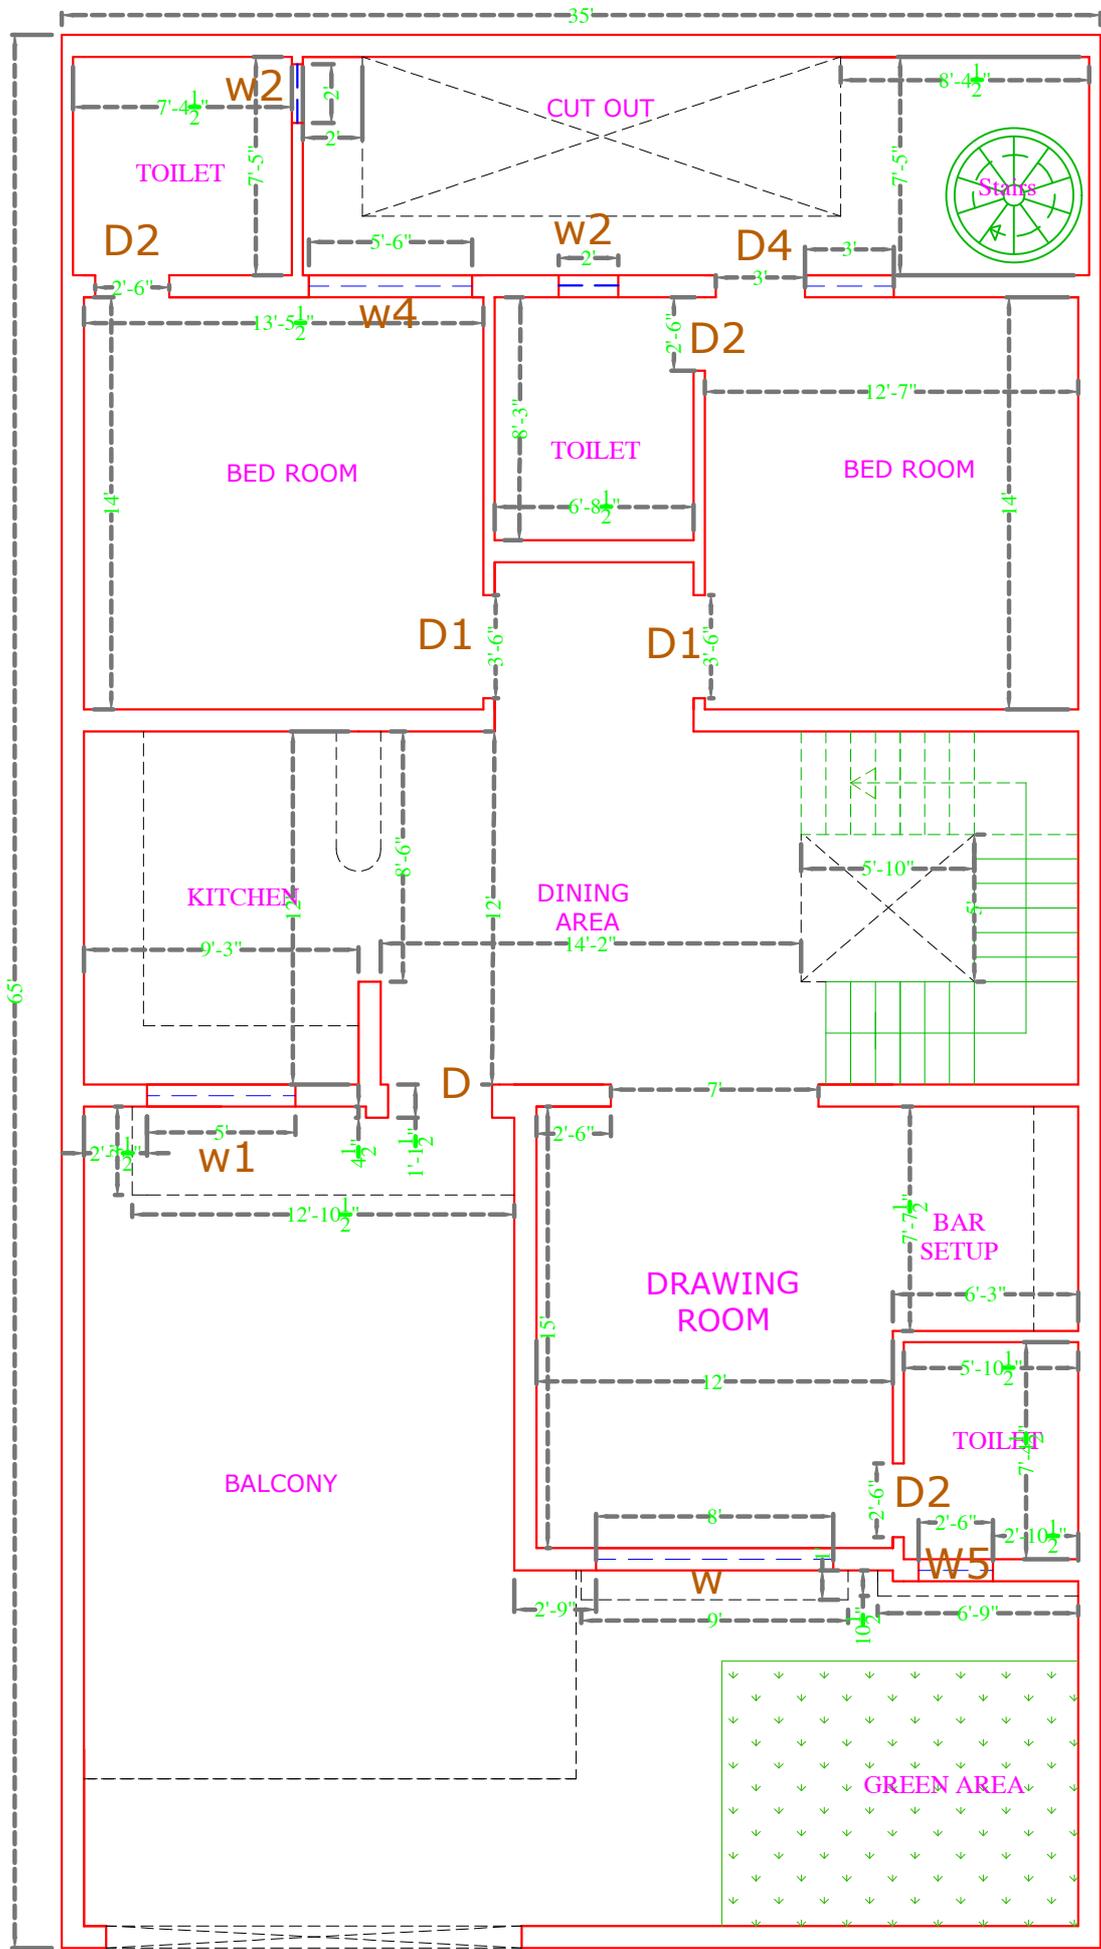


**BAWA ASSOCIATE**  
ARCHITECTURAL & INTERIOR DESIGNER

CAUTION  
While every attempt has been made in the preparation of this drawing to avoid mistakes, the maker cannot guarantee against human error. The contractor on the job must check all dimensions and other details and be responsible for the same.

**NOTES**

1. The drawing is the copyright of the architect and is not to be reproduced, copied, or handed over to a third party or used for any purpose other than that for which it is issued.
2. Do not scale off this drawing.
3. All dimensions are in feet unless otherwise stated.
4. This drawing is to be read in conjunction with relevant architectural, civil/structural, and services engineers' drawings and specifications.
5. All dimensions shall be checked on site prior to the start of work.
6. Written dimensions shall be followed.
7. Any change or discrepancy required shall be confirmed by the architect prior to the start of work.

**ONLY FOR DISCUSSION**

Project Title  
PROPOSED RESIDENCE FOR MR .

**BAWA ASSOCIATES**  
ER.GOVIND SINGH 8360595223  
BAWA 9780817682

2D & 3D Layout Design / Interior Designs / Interior Work / Front Elevation / Consultancy Services / Site Visiting / House Renovation Work

Location :-  
BAGORA GHANAUAR

Drawing Title  
Working Layout - First Floor

Scale Date Revision  
N.T.S. 22/09/2025

