

SIGN	NAME	HEIGHT
	SB	2'6"
	SB1	3'6"
	COB	AS
	FAN	AS
	LED TUBE	8'
	MCB	AS
	AC	8'
	SB2	6'



BAWA ASSOCIATE
ARCHITECTURAL & INTERIOR DESIGNER

NOTES
 1. The drawing is the copyright of the architect and is not to be reproduced, copied, or handed over to a third party or used for any purpose other than that for which it is issued.
 2. Do not scale off this drawing.
 3. All dimensions are in feet unless otherwise stated.
 4. This drawing is to be read in conjunction with relevant architectural, civil/structural, and services engineers' drawings and specifications.
 5. All dimensions shall be checked on site prior to the start of work.
 6. Written dimensions shall be followed.
 7. Any change or discrepancy required shall be confirmed by the architect prior to the start of work.

CADUTION
 While every attempt has been made in the preparation of this drawing to avoid mistakes, the maker cannot guarantee against human error. The contractor on the job must check all dimensions and other details and be responsible for the same.

ONLY FOR DISCUSSION


BAWA ASSOCIATES
 ER. GOVIND SINGH 8360595223
 BAWA 9780817682

2D & 3D Layout Designs / Interior Designs / Interior Work / Front Elevation / Consultancy Service / Site-Visiting / House Renovation Work

Project Title
 PROPOSED
 RESIDENCE
 FOR MR.



Location :-
 BAGORA GHANAUR
 Drawing Title :- First Floor
 Scale :- N.T.S. Date :- 22/09/2023
 Revision :-

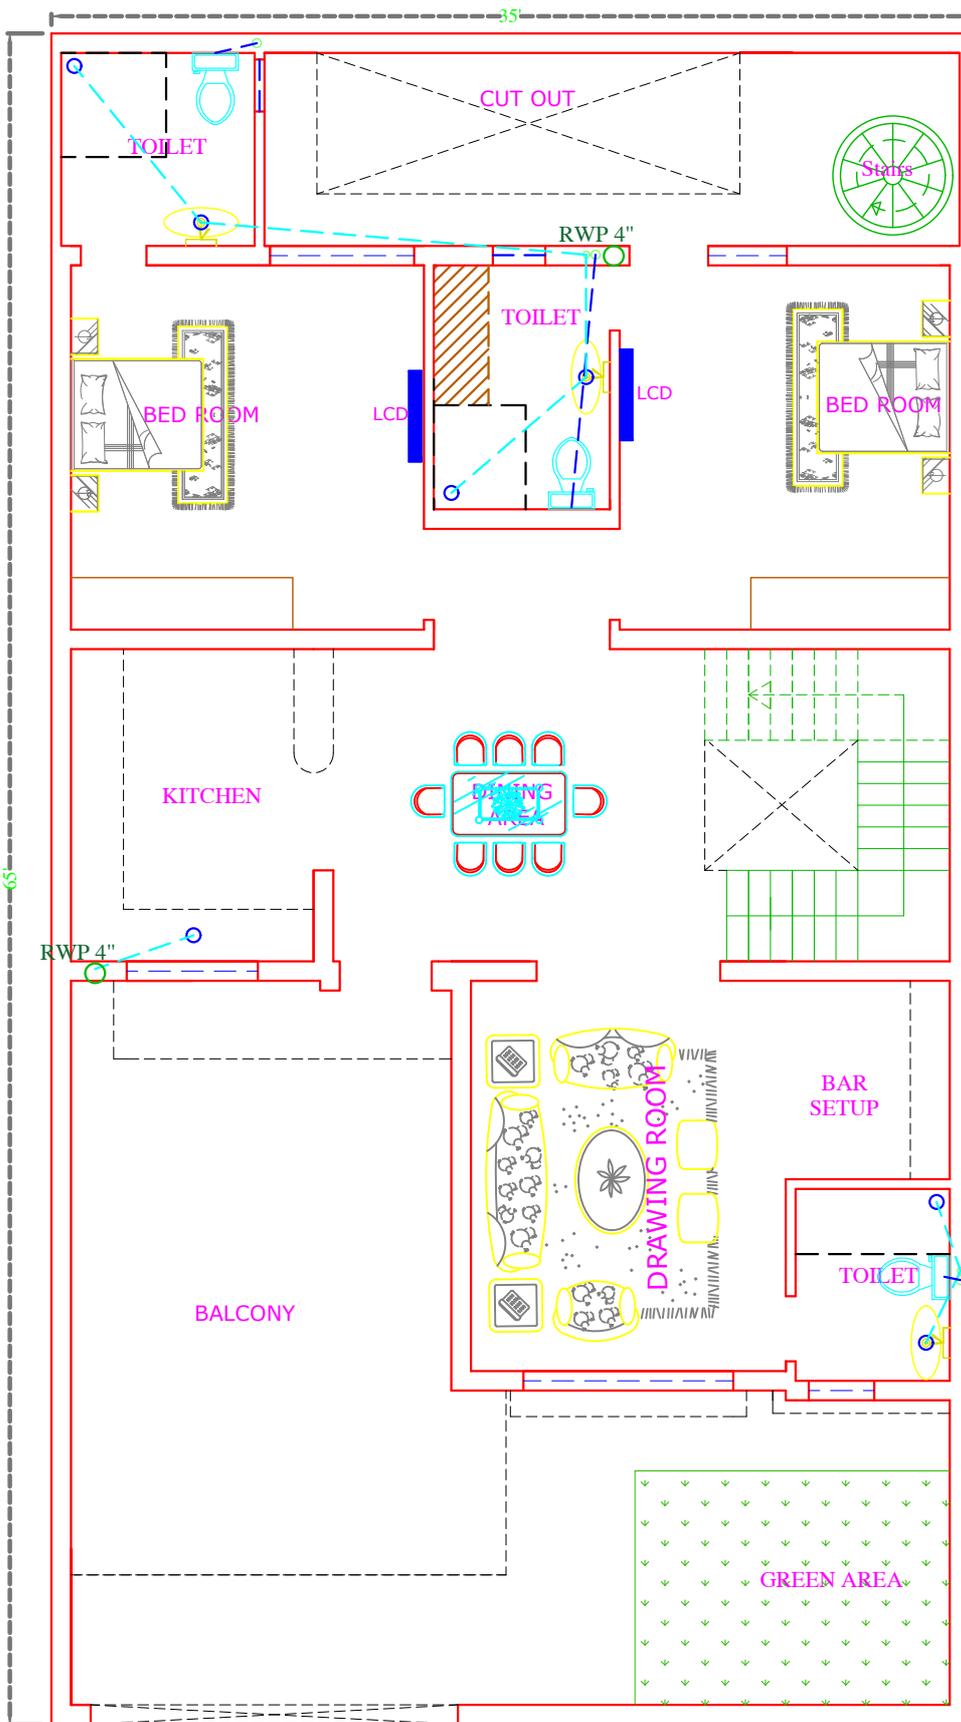

	RWP 4"
	WWP
	SWR
	FTP
	SWR 4"
	WWP
	WWP4"
	SWR4"
	SWR6"
	WWP 6"



BAWA ASSOCIATE
ARCHITECTURAL & INTERIOR DESIGNER

NOTES

1. The drawing is the copyright of the architect and is not to be reproduced, copied, or handed over to a third party or used for any purpose other than that for which it is issued.
2. Do not scale off this drawing.
3. All dimensions are in feet unless otherwise stated.
4. This drawing is to be read in conjunction with relevant architectural, civil/structural, and services engineers' drawings and specifications.
5. All dimensions shall be checked on site prior to the start of work.
6. Written dimensions shall be followed.
7. Any change or discrepancy required shall be confirmed by the architect prior to the start of work.

CAUTION
While every attempt has been made in the preparation of this drawing to avoid mistakes, the maker cannot guarantee against human error. The contractor on the job must check all dimensions and other details and be responsible for the same.

ONLY FOR DISCUSSION

BAWA ASSOCIATES
ER.GOVIND SINGH 9360595223
BAWA 9780817682
2D & 3D Layout Design/ Interior Design/ Interior Work / Front Elevation / Consultancy Service/ Site Visiting / House Renovation Work

Project Title
PROPOSED RESIDENCE
FOR MR .



Location :- BAGORA GHANAUR
Drawing Title
Drawing Date :- Ground Floor
Scale N.T.S Date 22/09/2025 Revision



NOTES
 1. The drawing is the copyright of the architect and is not to be reproduced, copied, or handed over to a third party or used for any purpose other than that for which it is issued.
 2. Do not scale off this drawing.
 3. All dimensions are in feet unless otherwise stated.
 4. This drawing is to be read in conjunction with relevant architectural, civil/structural, and services engineers' drawings and specifications.
 5. All dimensions shall be checked on site prior to the start of work.
 6. Written dimensions shall be followed.
 7. Any change or discrepancy required shall be confirmed by the architect prior to the start of work.

CAUTION
 While every attempt has been made in the preparation of this drawing to avoid mistakes, the maker cannot guarantee against human error. The contractor on the job must check all dimensions and other details and be responsible for the same.

ONLY FOR DISCUSSION
 Project Title
 PROPOSED RESIDENCE FOR MR .

BAWA ASSOCIATES
 ER.GOVIND SINGH 8360595223
 BAWA 9780817682
 2D & 3D Layout Designs / Interior Designs / Interior Work / Front Elevation / Consultancy Service / Site Visiting / House Renovation Work


Location :-
 BAGORA GHANAUR


Drawing Title
 Joinery Layout - First Floor

Scale
 N.T.S

Date
 22/09/2025

Revision.

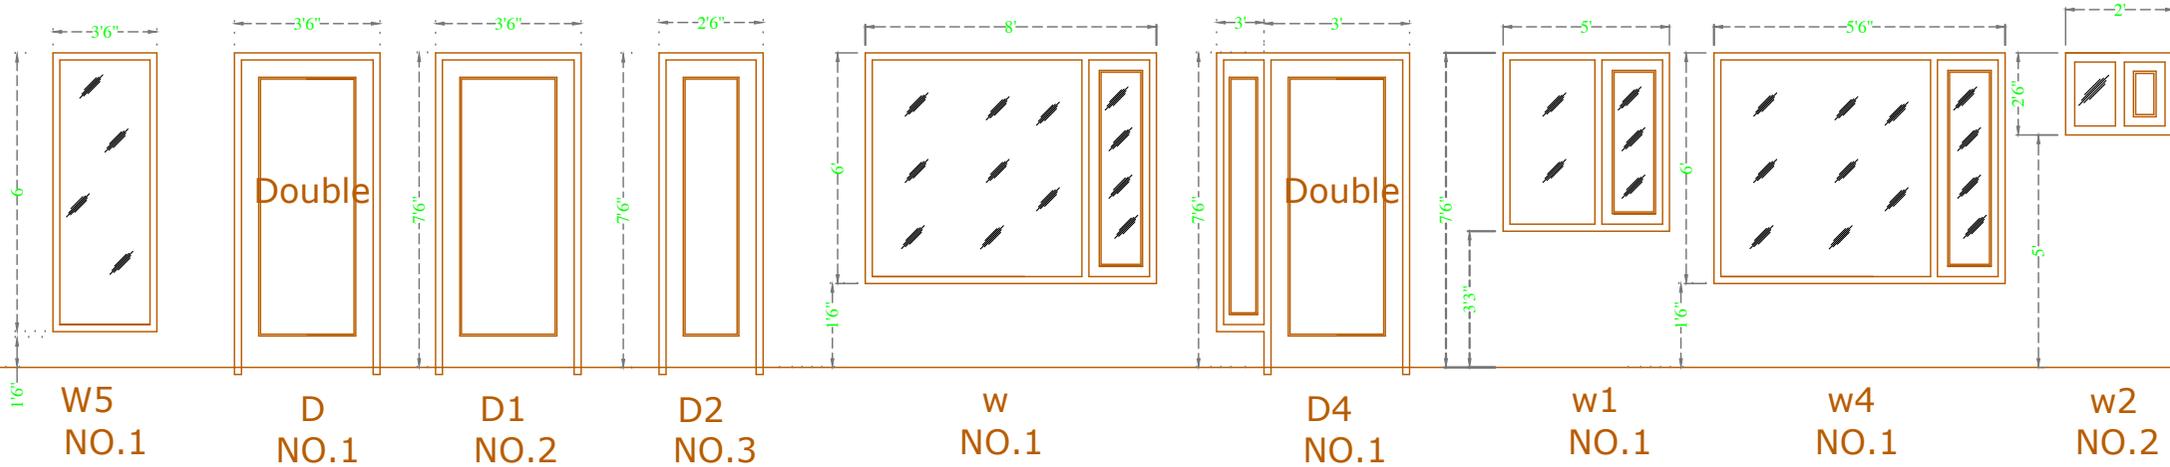

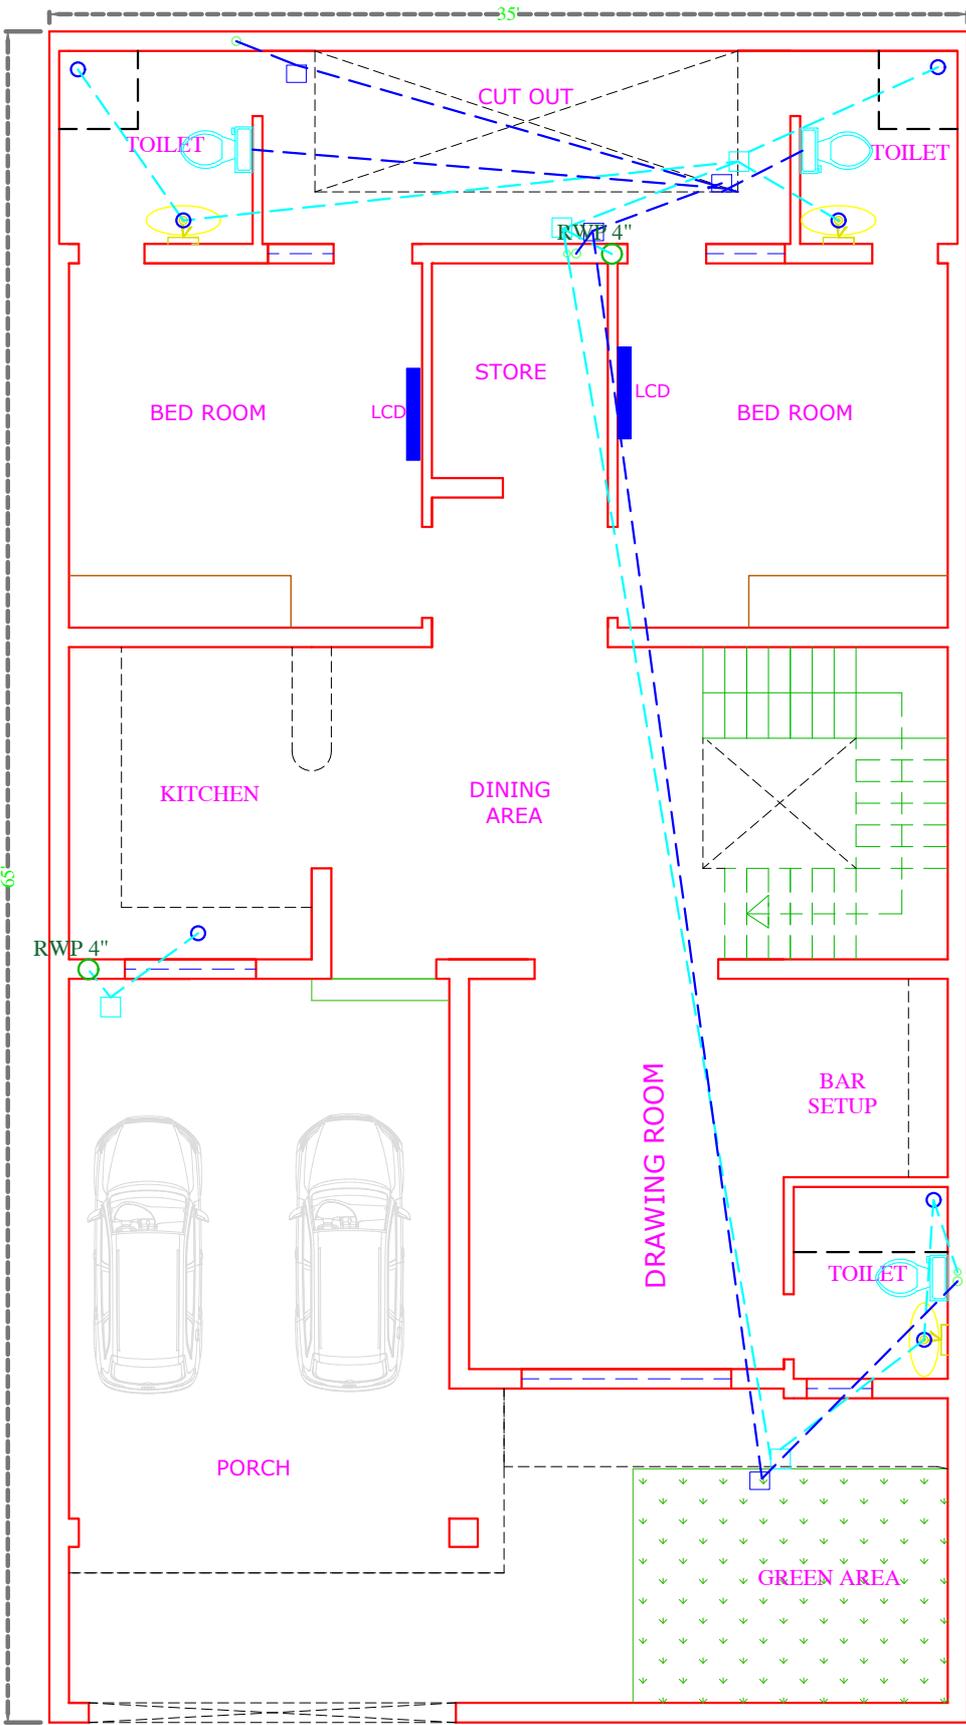

	RWP 4"
	WWP
	SWR
	FTP
	SWR 4"
	WWP
	WWP4"
	SWR4"
	SWR6"
	WWP 6"



BAWA ASSOCIATE
ARCHITECTURAL & INTERIOR DESIGNER

NOTES

- The drawing is the copyright of the architect and is not to be reproduced, copied, or handed over to a third party or used for any purpose other than that for which it is issued.
- Do not scale off this drawing.
- All dimensions are in feet unless otherwise stated.
- This drawing is to be read in conjunction with relevant architectural, civil/structural, and services engineers' drawings and specifications.
- All dimensions shall be checked on site prior to the start of work.
- Written dimensions shall be followed.
- Any change or discrepancy required shall be confirmed by the architect prior to the start of work.

CAUTION
While every attempt has been made in the preparation of this drawing to avoid mistakes, the maker cannot guarantee against human error. The contractor on the job must check all dimensions and other details and be responsible for the same.

ONLY FOR DISCUSSION

BAWA ASSOCIATES
ER.GOVIND SINGH 8360595223
BAWA 9780817682

2D & 3D Layout Design / Interior Designes / Interior Work / Front Elevation / Consultancy Services / Site Visiting / House Renovation Work

Project Title
PROPOSED RESIDENCE
FOR MR .



Location :- BAGORA GHANAUR

Drawing Title	Date
Revision	22/09/2025



NOTES
 1. The drawing is the copyright of the architect and is not to be reproduced, copied, or handed over to a third party or used for any purpose other than that for which it is issued.
 2. Do not scale off this drawing.
 3. All dimensions are in feet unless otherwise stated.
 4. This drawing is to be read in conjunction with relevant architectural, civil/structural, and services engineers' drawings and specifications.
 5. All dimensions shall be checked on site prior to the start of work.
 6. Written dimensions shall be followed.
 7. Any change or discrepancy required shall be confirmed by the architect prior to the start of work.

CAUTION
 While every attempt has been made in the preparation of this drawing to avoid mistakes, the maker cannot guarantee against human error. The contractor on the job must check all dimensions and other details and be responsible for the same.


ONLY FOR DISCUSSION
Project Title
 PROPOSED RESIDENCE FOR MR .


BAWA ASSOCIATES
 ER.GOVIND SINGH 8360595223
 BAWA 9780817682
2D & 3D Layout Designs / Interior Designs / Interior Work / Front Elevation / Consultancy Service / Site Visiting / House Renovation Work

Location :-
 BAGORA GHANAUR

Drawing Title
 Joinery Layout - Ground Floor

Scale N.T.S	Date 22/09/2025	Revision.
----------------	--------------------	--------------------

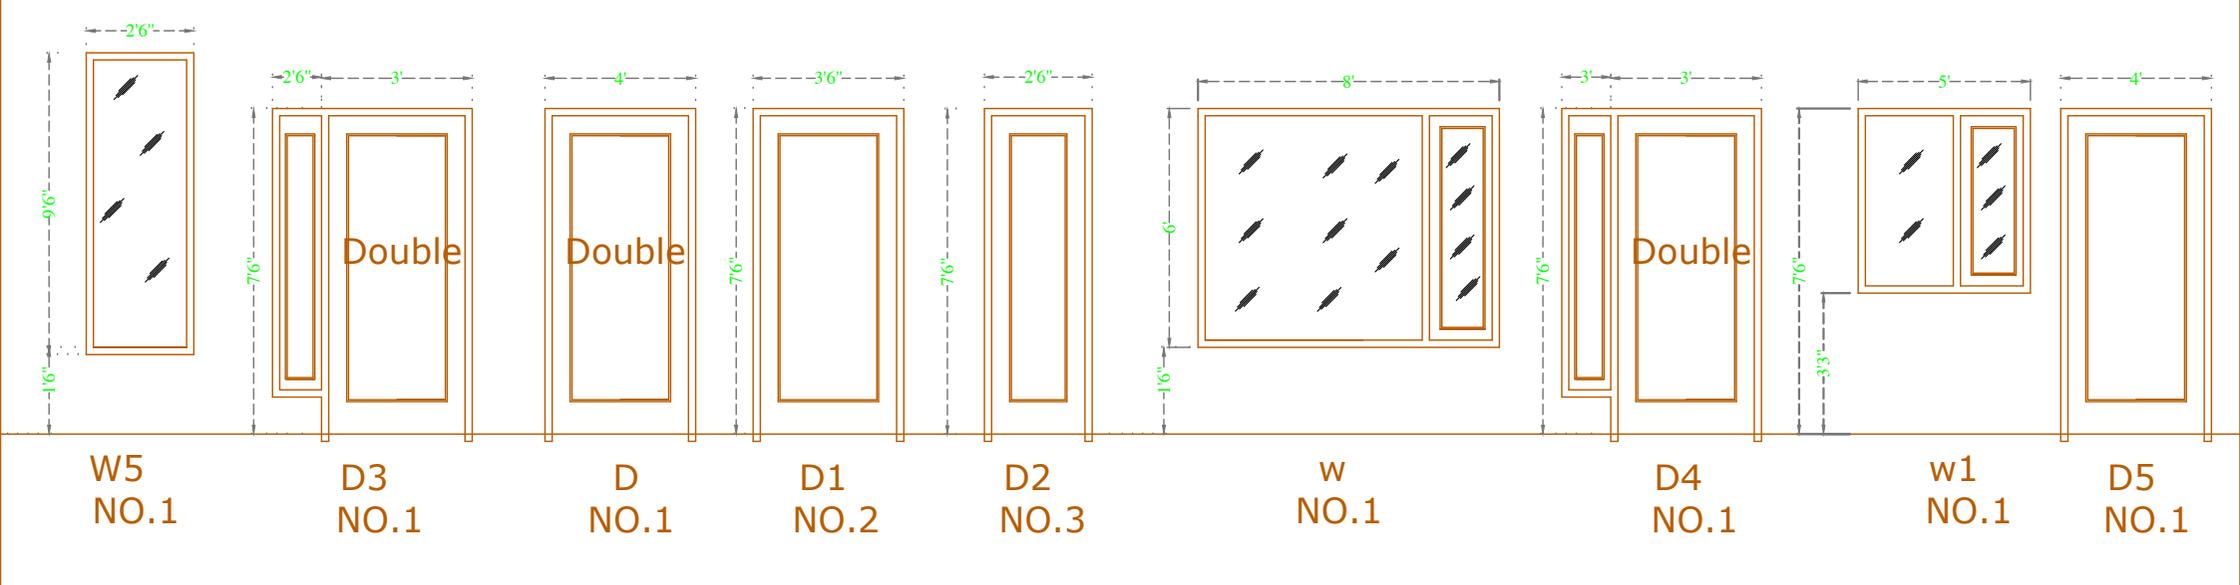

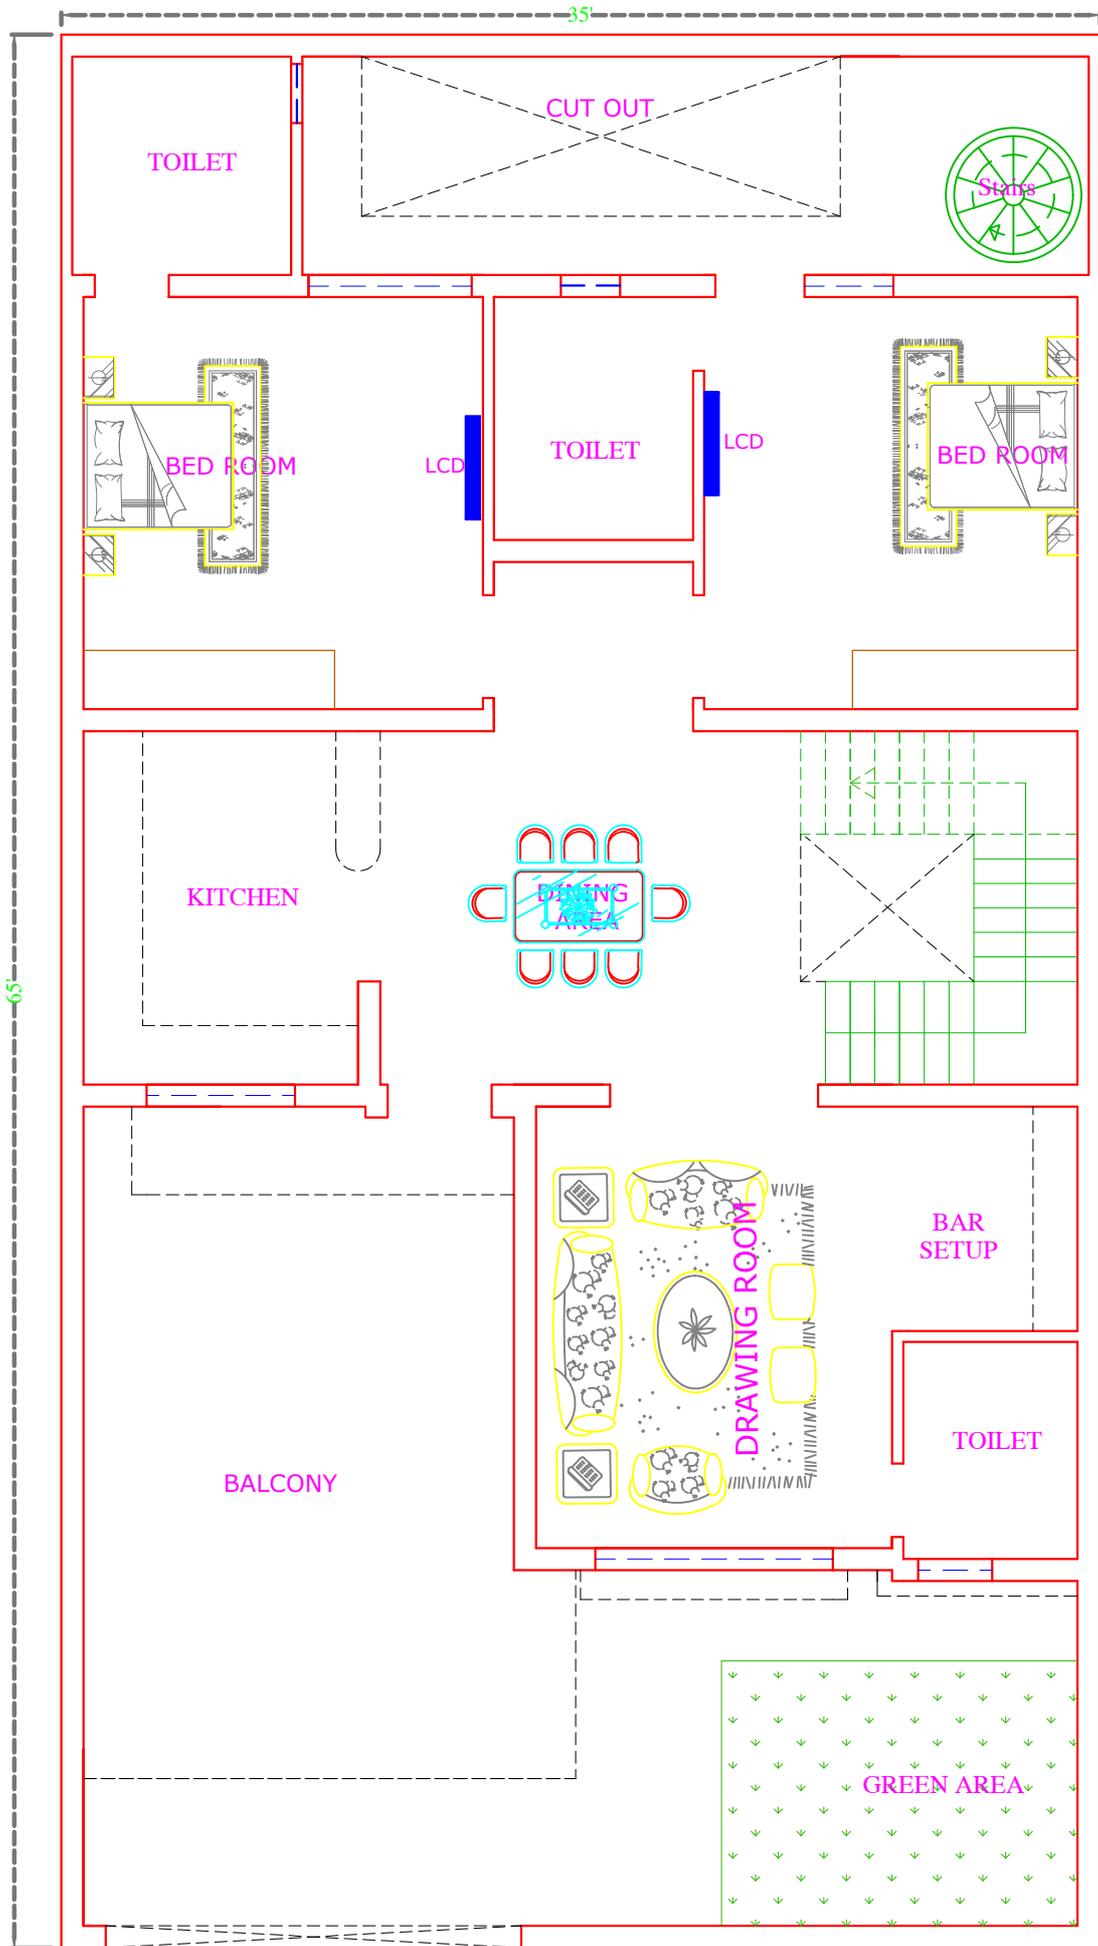

BAWA ASSOCIATE
ARCHITECTURAL & INTERIOR DESIGNER

CAUTION
While every attempt has been made in the preparation of this drawing to avoid mistakes, the maker cannot guarantee against human error. The contractor on the job must check all dimensions and other details and be responsible for the same.

NOTES

1. The drawing is the copyright of the architect and is not to be reproduced, copied, or handed over to a third party or used for any purpose other than that for which it is issued.
2. Do not scale off this drawing.
3. All dimensions are in feet unless otherwise stated.
4. This drawing is to be read in conjunction with relevant architectural, civil/structural, and services engineers' drawings and specifications.
5. All dimensions shall be checked on site prior to the start of work.
6. Written dimensions shall be followed.
7. Any change or discrepancy required shall be confirmed by the architect prior to the start of work.

ONLY FOR DISCUSSION

Project Title
PROPOSED RESIDENCE FOR MR .


BAWA ASSOCIATES
ER.GOVIND SINGH 8360595223
BAWA 9780817682

2D & 3D Layout Design / Interior Designs / Interior Work / Front Elevation / Consultancy Service / Site Visiting / House Renovation Work

Location :-
BAGORA GHANAUR

Drawing Title
Master plan Layout - First Floor

Scale N.T.S. Date 22/09/2025 Revision

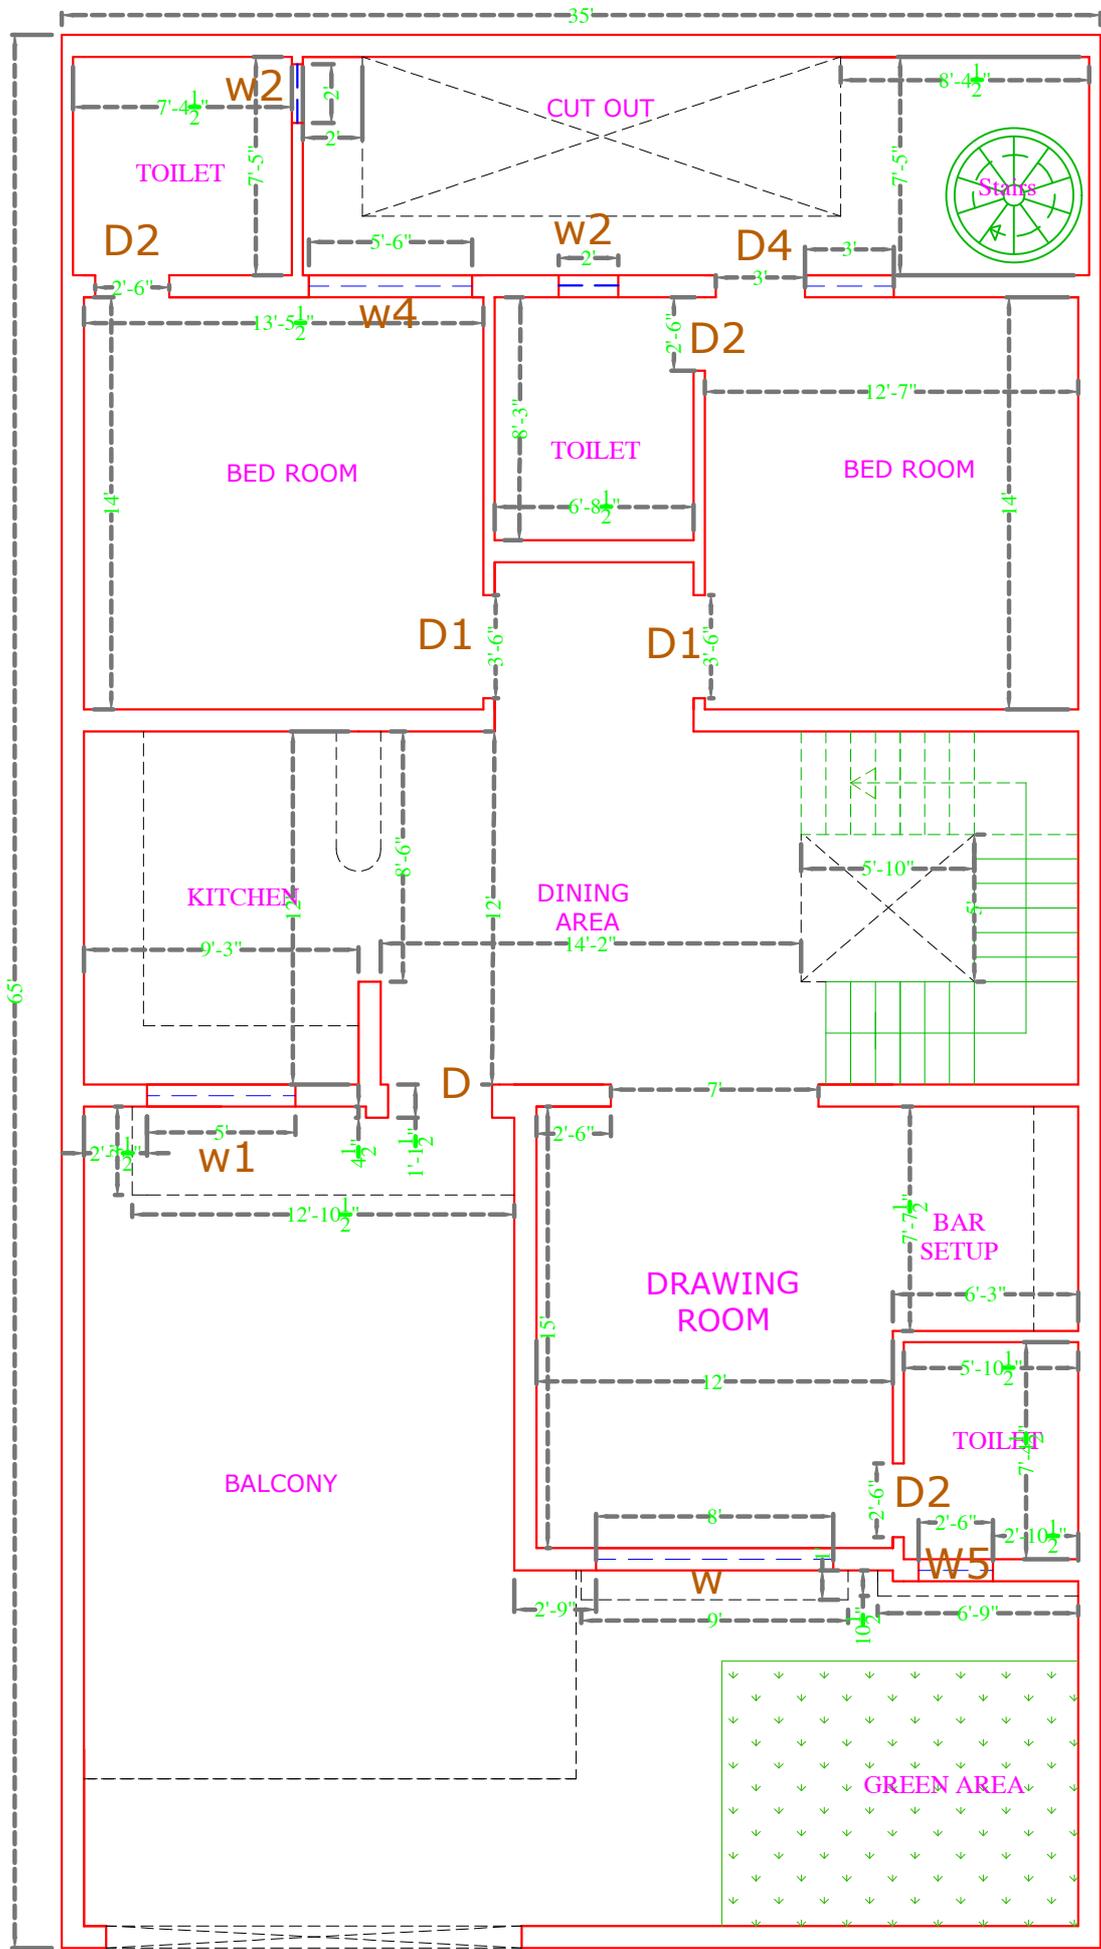

NOTES

1. The drawing is the copyright of the architect and is not to be reproduced, copied, or handed over to a third party or used for any purpose other than that for which it is issued.
2. Do not scale off this drawing.
3. All dimensions are in feet unless otherwise stated.
4. This drawing is to be read in conjunction with relevant architectural, civil/structural, and services engineers' drawings and specifications.
5. All dimensions shall be checked on site prior to the start of work.
6. Written dimensions shall be followed.
7. Any change or discrepancy required shall be confirmed by the architect prior to the start of work.

ONLY FOR DISCUSSION

Project Title
 PROPOSED RESIDENCE FOR MR .

BAWA ASSOCIATES
 ER.GOVIND SINGH 8360595223
 BAWA 9780817682


2D & 3D Layout Design / Interior Designs / Interior Work / Front Elevation / Consultancy Services / Site Visiting / House Renovation Work

Location :-
 BAGORA GHANAUAR

Drawing Title
 Working Layout - First Floor

Scale Date Revision
 N.T.S. 22/09/2025



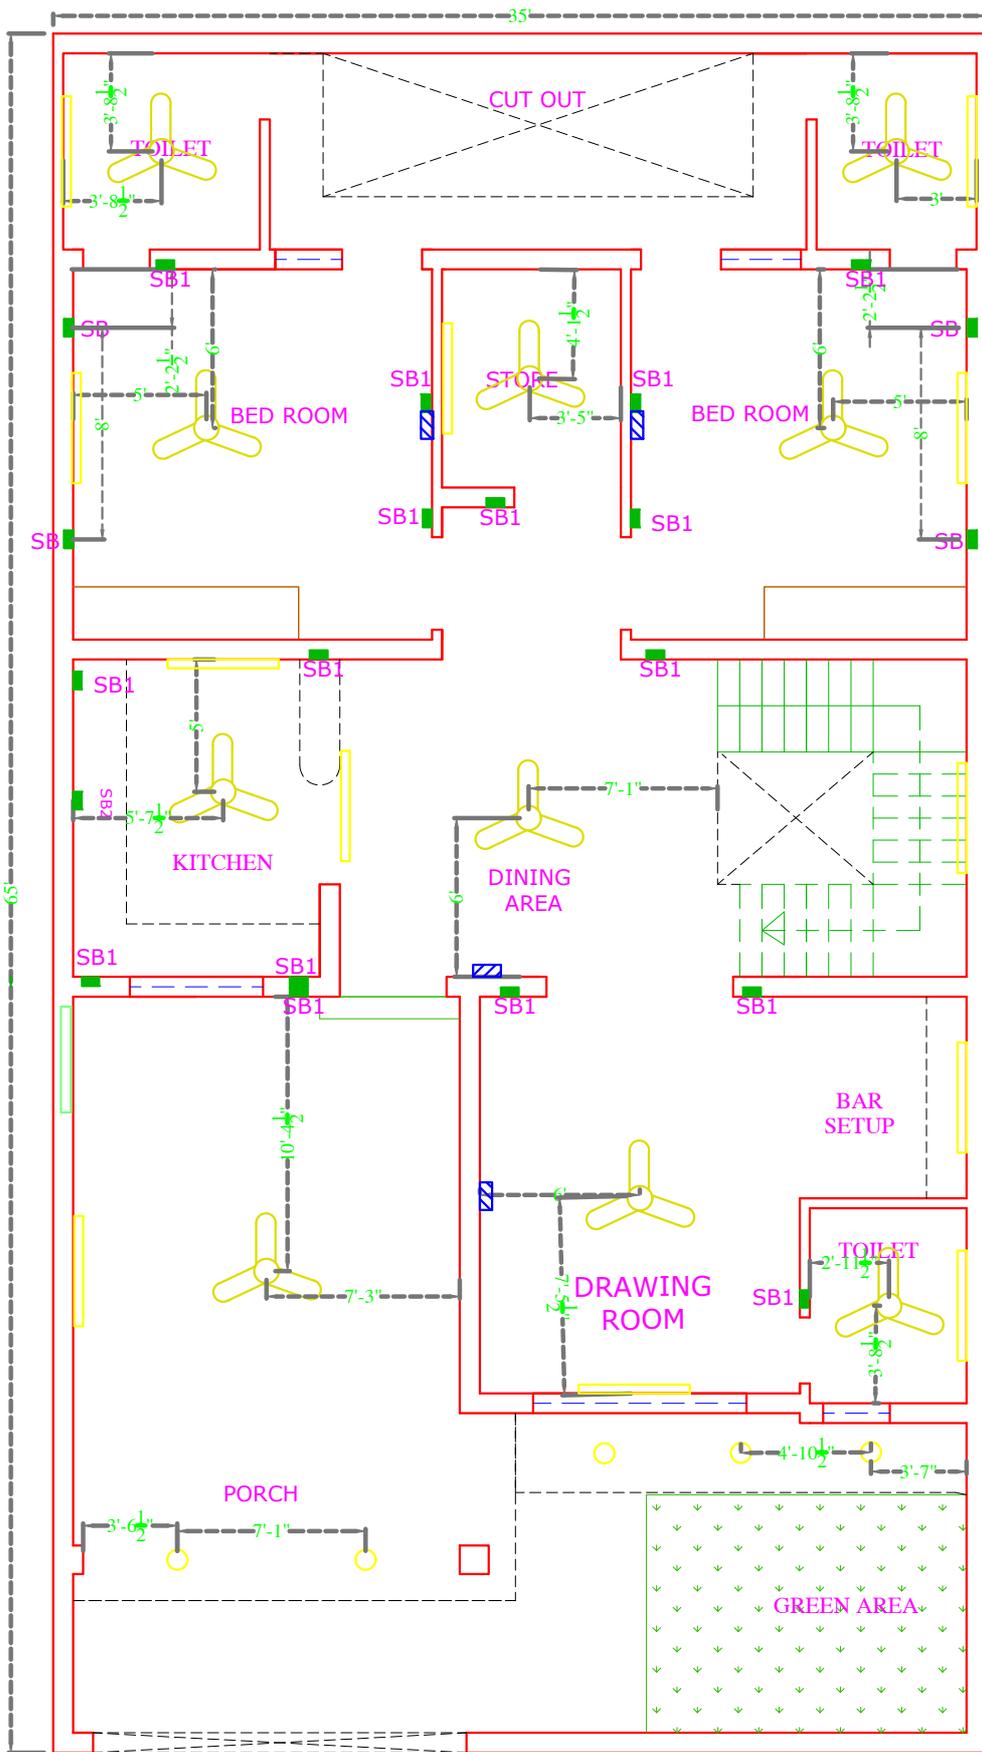

SIGN	NAME	HEIGHT
	SB	2'6"
	SB1	3'6"
	COB	AS
	FAN	AS
	LED TUBE	8'
	MCB	AS
	AC	8'
	SB2	6'



BAWA ASSOCIATE
ARCHITECTURAL & INTERIOR DESIGNER

NOTES
 1. The drawing is the copyright of the architect and is not to be reproduced, copied, or handed over to a third party or used for any purpose other than that for which it is issued.
 2. Do not scale off this drawing.
 3. All dimensions are in feet unless otherwise stated.
 4. This drawing is to be read in conjunction with relevant architectural, civil/structural, and services engineers' drawings and specifications.
 5. All dimensions shall be checked on site prior to the start of work.
 6. Written dimensions shall be followed.
 7. Any change or discrepancy required shall be confirmed by the architect prior to the start of work.

CAUTION
 While every attempt has been made in the preparation of this drawing to avoid mistakes, the maker cannot guarantee against human error. The contractor on the job must check all dimensions and other details and be responsible for the same.

ONLY FOR DISCUSSION

BAWA ASSOCIATES
 ER. GOVIND SINGH 8360595223
 BAWA 9780817682
 2D & 3D Layout Designs / Interior Designs / Interior Work / Front Elevation / Consultancy Service / Site Visiting / House Renovation Work

Project Title
 PROPOSED RESIDENCE
 FOR MR .



Location :-
 BAGORA GHANAUR
 Drawing Title
 Electrical Plan Ground Floor
 Scale N.T.S Date 22/09/2023 Revision